

**PODILA
SRAVAN
KUMAR**

Digitally signed by
PODILA SRAVAN
KUMAR
Date: 2024.04.06
13:04:51 +05'30'

PROJECT TITLE - PLAN SHOWING THE PROPOSED RESIDENTIAL APARTMENTS CONSISTING OF 1 RESIDENTIAL TOWER WITH 3 WINGS EACH CONSISTING OF 6 COMMON BASEMENT + GROUND FLOOR + AMENITIES (1st & 2nd FLOOR) + 52/48/48 UPPER FLOORS (IN WING 1 / 2 / 3) AND ITITES BUILDING IN SY NO 272P & 273P, PUPPALGUDA VILLAGE, GANDIPET MANDAL, RANGAREDDY DISTRICT, TELANGANA-REG.

BELONGS TO-
M/S PHOENIX GLOBAL SPACES PVT LTD

- GENERAL NOTES
1. ALL DIMENSIONS IN THIS DRAWING ARE IN MILLIMETERS.
 2. ONLY WRITTEN DIMENSIONS ARE TO BE FOLLOWED. THE DRAWING SHOULD NOT BE SCALED UNDER ANY CIRCUMSTANCES.
 3. ALL MEASUREMENTS MUST BE CHECKED & VERIFIED BY THE CONTRACTORS PRIOR TO EXECUTION OF WORK AT SITE.
 4. THIS DRAWING IS TO BE READ IN CONJUNCTION WITH ALL RELEVANT STRUCTURAL SERVICES & FACILITY PLANNING DRAWINGS.
 5. ANY DISCREPANCIES BETWEEN ARCHITECTURAL, STRUCTURAL & SERVICES DRAWINGS MUST BE BROUGHT INTO NOTICE OF THE ARCHITECT'S IMMEDIATELY PRIOR TO EXECUTION AT SITE CO-ORDINATION BETWEEN THE DRAWINGS WHAT SO-EVER IS THE RESPONSIBILITY OF CONTRACTORS.
 6. ALL MASONRY WALLS SHOULD BE ALIGNED WITH THE COLUMNS AS INDICATED IN THE DRAWING IRRESPECTIVE OF THE POSITION AS CALCULATED WITH THE DIMENSIONING.
 7. FOR DETAILS, PLEASE REFER RELEVANT LARGER SCALE DETAILED DRAWINGS AS WHEN INDICATED.
 8. IN CASE OF ALL SPECIALIST WORKS, DETAILS AND ANY DEVIATIONS FROM THIS CONSTRUCTION DRAWING, THE CONTRACTOR HAS TO PROVIDE SHOP DRAWINGS FOR ARCHITECT'S APPROVAL PRIOR TO CONSTRUCTION.


No.	Description	Date

CLIENT:
Phoenix
M/s PHOENIX GLOBAL SPACES PVT.LTD
A # 12/10 Road No-45, Jubilee Hills Hyderabad

LEAD CONSULTANT / ARCHITECTS:
ASURE DESIGN STUDIO
3rd Floor, Foyyappa One Tower,
Beside Madhavaraj Public Station,
Hitech City Road, Hyderabad, Telangana.

STRUCTURAL CONSULTANT:
STRUDCOM CONSULTANTS PVT. LTD.
OFFICE NO. 201-2ND FLOOR, E-GHANTA, E16 NO. 136, PLOT NO. 8,
ERANDOWANE, PUNE-411004

HVAC, ELECTRICAL PHE & FIRE CONSULTANTS:
QDC
QDC INDIA CONSULTING (P) LTD.,
STRUCTURAL & MEP CONSULTANTS
W-14, 1st Floor, Madhavaraj Public Station,
1st Floor, Madhavaraj Public Station, Hitech City,
Hyderabad, Telangana. www.qdcindia.com

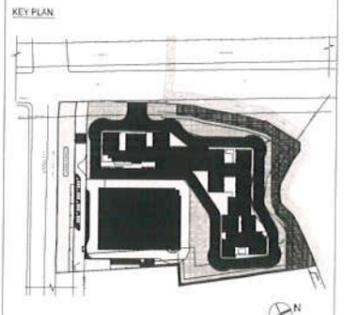


PROJECT TITLE
PHOENIX P25- TRITON
SURVEY NO 272P & 273P
PUPPALGUDA VILLAGE, GANDIPET MANDAL, RANGAREDDY DISTRICT,
TELANGANA-REG.

DWG STATUS:

DWG TITLE: **SECOND FLOOR PLAN**

DATE	SCALE	ORIENTATION

DRAWN	CHECKED	REVISION

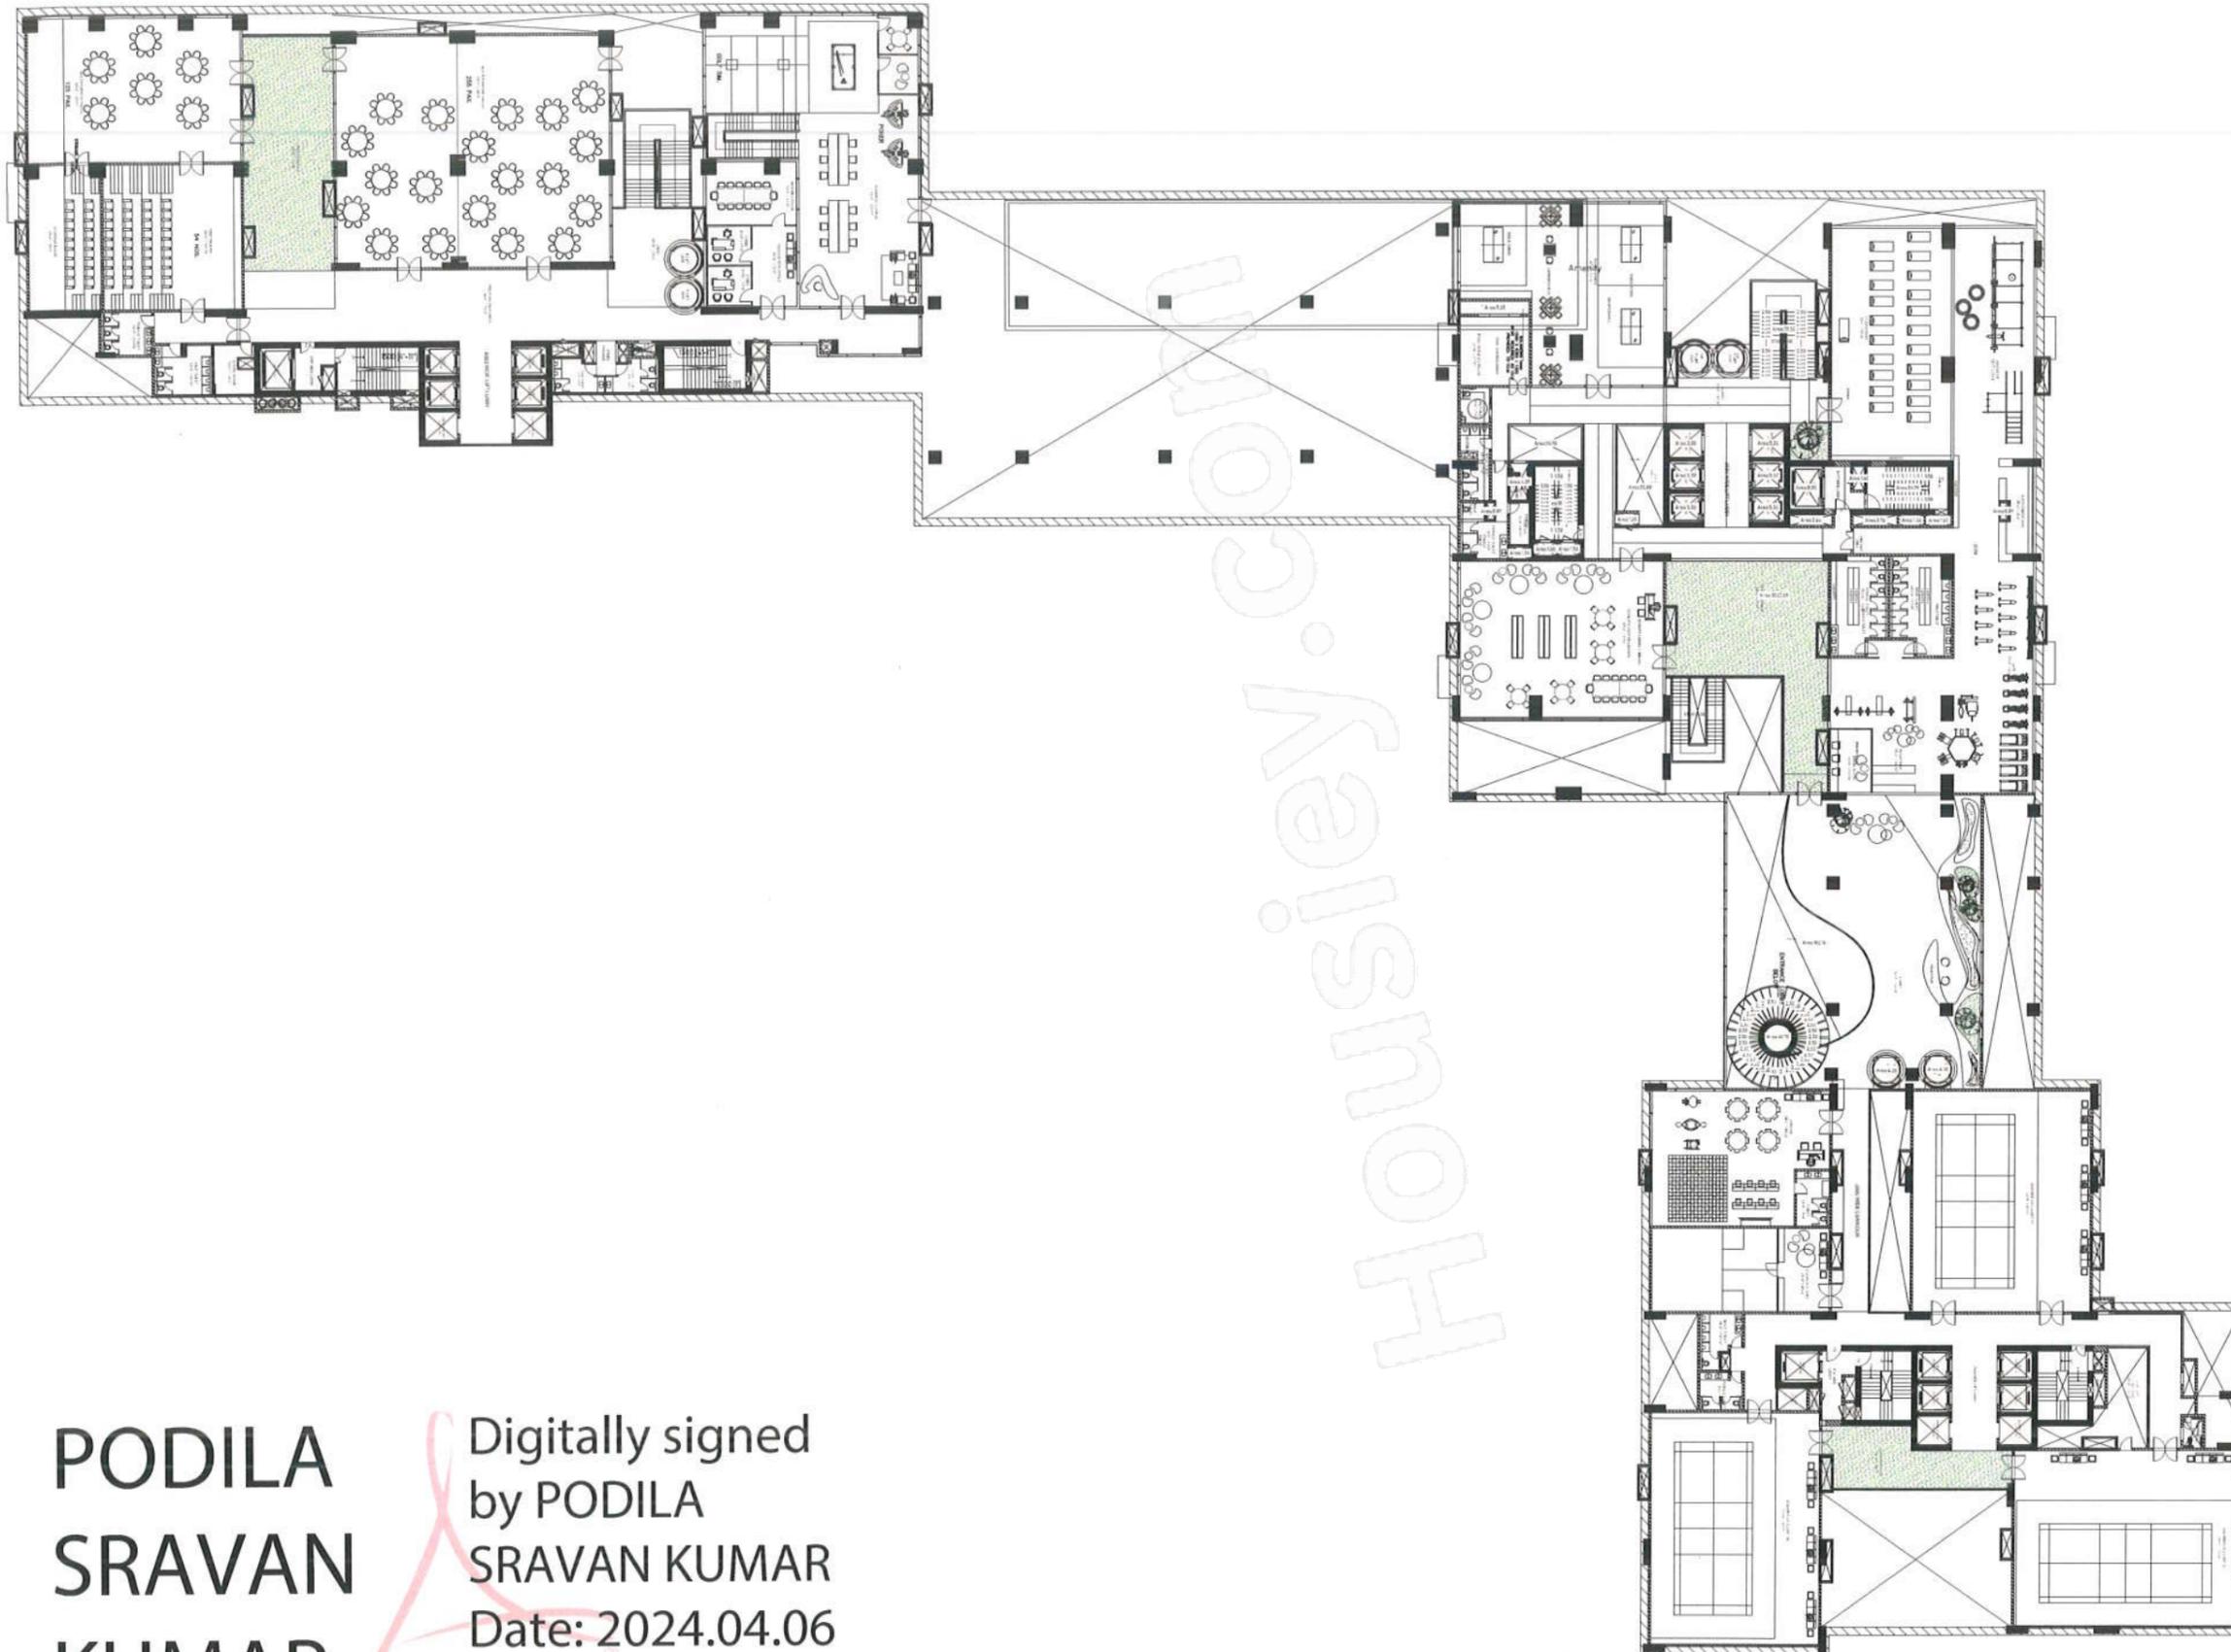

PROJECT TITLE - PLAN SHOWING THE PROPOSED RESIDENTIAL APARTMENTS CONSISTING OF 1 RESIDENTIAL TOWER WITH 3 WINGS EACH CONSISTING OF 6 COMMON BASEMENT + GROUND FLOOR + AMENITIES (1st & 2nd FLOOR) + 52/49/48 UPPER FLOORS (IN WING 1 / 2 / 3) AND ITITES BUILDING IN SY NO 272P & 273P, PUPPALGUDA VILLAGE, GANDIPET MANDAL, RANGAREDDY DISTRICT, TELANGANA-REG.

BELONG TO -
M/S PHOENIX GLOBAL SPACES PVT LTD

- GENERAL NOTES
1. ALL DIMENSIONS IN THIS DRAWING ARE IN MILLIMETERS.
 2. ONLY WRITTEN DIMENSIONS ARE TO BE FOLLOWED. THE DRAWING SHOULD NOT BE SCALED UNDER ANY CIRCUMSTANCES.
 3. ALL MEASUREMENTS MUST BE CHECKED & VERIFIED BY THE CONTRACTORS PRIOR TO EXECUTION OF WORK AT SITE.
 4. THIS DRAWING IS TO BE READ IN CONJUNCTION WITH ALL RELEVANT STRUCTURAL SERVICES & FACILITY PLANNING DRAWINGS.
 5. ANY DISCREPANCIES BETWEEN ARCHITECTURAL, STRUCTURAL & SERVICES DRAWINGS MUST BE BROUGHT INTO NOTICE OF THE ARCHITECTS IMMEDIATELY PRIOR TO EXECUTION AT SITE. CO-ORDINATION BETWEEN THE DRAWINGS WHAT GO-EVER IS THE RESPONSIBILITY OF CONTRACTORS.
 6. ALL MASONRY WALLS SHOULD BE ALIGNED WITH THE COLUMNS AS INDICATED IN THE DRAWING IRRESPECTIVE OF THE POSITION AS CALCULATED WITH THE DIMENSIONING.
 7. FOR DETAILS, PLEASE REFER RELEVANT LARGER SCALE DETAILED DRAWINGS AS WHEN INDICATED.
 8. IN CASE OF ALL SPECIALIST WORKS, DETAILS AND ANY DEVIATIONS FROM THIS CONSTRUCTION DRAWING, THE CONTRACTOR HAS TO PROVIDE SHOP DRAWINGS FOR ARCHITECTS APPROVAL PRIOR TO CONSTRUCTION.

No.	Description	Date

CLIENT
Phoenix
M/S. PHOENIX GLOBAL SPACES PVT.LTD
A #1122 Road No-42, Jubilee Hills, Hyderabad

LEAD CONSULTANT / ARCHITECTS
ASURE DESIGN STUDIO
3rd Floor, Appara One Tower,
Secundrabad Police Station,
Hitech City Road Hyderabad, Telangana.

STRUCTURAL CONSULTANT
STRUDCOM CONSULTANTS PVT. LTD.
OFFICE NO.201, 2ND FLOOR, ERDANTA, CTE NO.136 PLOT NO.8
ERANDWANE, PUNE-411004

HVAC, ELECTRICAL, P&E & FIRE CONSULTANTS
QDC
QDC INDIA CONSULTING (P) LTD.,
STRUCTURAL & MEP CONSULTANTS
M/s. Prakash Management Systems
101/102, "Sudhakar" Building, 2nd Floor,
4th Block, 10th Cross, www.qdcindia.com



PROJECT TITLE
PHOENIX P25- TRITON
SURVEY NO 272P, 273P
PUPPALGUDA VILLAGE, GANDIPET MANDAL, RANGAREDDY DISTRICT
TELANGANA-REG

DWG STATUS:
DWG TITLE:
FIRST FLOOR PLAN

DATE	SCALE	ORIENTATION
DRAWN	CHECKED	
DRAWING NO		REVISION

**PODILA
SRAVAN
KUMAR**

Digitally signed
by PODILA
SRAVAN KUMAR
Date: 2024.04.06
13:05:31 +05'30'

PODILA SRAVAN KUMAR

Digitally signed by PODILA SRAVAN KUMAR
Date: 2024.04.06 13:06:28 +05'30'

PROJECT TITLE - PLAN SHOWING THE PROPOSED RESIDENTIAL APARTMENTS CONSISTING OF 1 RESIDENTIAL TOWER WITH 3 WINGS EACH CONSISTING OF 6 COMMON BASEMENT + GROUND FLOOR + AMENITIES (1st & 2nd FLOOR) + 52-48/48 UPPER FLOORS IN WING 1 / 2 / 3; AND ITITES BUILDING IN SV NO 27/2P & 27/3P, PUFFALOGGA VILLAGE, GANGPET MANDAL, RANGAREDDY DISTRICT, TELANGANA - REG.

BELONG TO -
M/S PHOENIX GLOBAL SPACES PVT LTD

- GENERAL NOTES
1. ALL DIMENSIONS IN THIS DRAWING ARE IN MILLIMETERS.
 2. ONLY WRITTEN DIMENSIONS ARE TO BE FOLLOWED. THE DRAWING SHOULD NOT BE SCALED UNDER ANY CIRCUMSTANCES.
 3. ALL MEASUREMENTS MUST BE CHECKED & VERIFIED BY THE CONTRACTORS PRIOR TO EXECUTION OF WORK AT SITE.
 4. THIS DRAWING IS TO BE READ IN CONJUNCTION WITH ALL RELEVANT STRUCTURAL SERVICES & FACILITY PLANNING DRAWINGS.
 5. ANY DISCREPANCIES BETWEEN ARCHITECTURAL, STRUCTURAL & SERVICES DRAWINGS MUST BE BROUGHT INTO NOTICE OF THE ARCHITECTS IMMEDIATELY PRIOR TO EXECUTION AT SITE. CO-ORDINATION BETWEEN THE DRAWINGS WHAT SO EVER IS THE RESPONSIBILITY OF CONTRACTORS.
 6. ALL MASONRY WALLS SHOULD BE ALIGNED WITH THE COLUMNS AS INDICATED IN THE DRAWING IRRESPECTIVE OF THE POSITION AS CALCULATED WITH THE DIMENSIONING.
 7. FOR DETAILS, PLEASE REFER LARGER SCALE DETAILED DRAWINGS AS WHEN INDICATED.
 8. IN CASE OF ALL SPECIALIST WORKS, DETAILS AND ANY DEVIATIONS FROM THIS CONSTRUCTION DRAWING, THE CONTRACTOR HAS TO PROVIDE SHOP DRAWINGS FOR ARCHITECTS APPROVAL PRIOR TO CONSTRUCTION.

No.	Description	Date

CLIENT:
Phoenix
M/s. PHOENIX GLOBAL SPACES PVT. LTD
A #123 Road No. 45, Jubilee Hills Hyderabad

LEAD CONSULTANT / ARCHITECTS:
ASURE DESIGN STUDIO
3rd Floor, Ashoka One Tower,
Shiloh, Madhapur, Hyderabad,
Hyderabad, Telangana.

STRUCTURAL CONSULTANT:
STRUDCOM CONSULTANTS PVT. LTD.
OFFICE NO. 201, 2ND FLOOR, EKANTARA, CTS NO. 136, PLOT NO. 8,
ERANDIYANA, HYDRABAD.

HVAC, ELECTRICAL, PHE & FIRE CONSULTANTS:
QDC
QDC INDIA CONSULTING (P) LTD.
STRUCTURAL & MEP CONSULTANTS
#12, 1st Floor, Madhapur, Hyderabad,
#12, 1st Floor, Madhapur, Hyderabad, 500081
#12, 1st Floor, Madhapur, Hyderabad, 500081




PROJECT TITLE:
PHOENIX P25- TRITON
SURVEY NO 27/2P
PUFFALOGGA VILLAGE, GANGPET MANDAL, RANGAREDDY DISTRICT,
TELANGANA-REG.

DWG. STATUS:

DWG. TITLE: **SECTION_B-B**


DATE	SCALE	ORIENTATION

DRAWN	CHECKED	REVISION

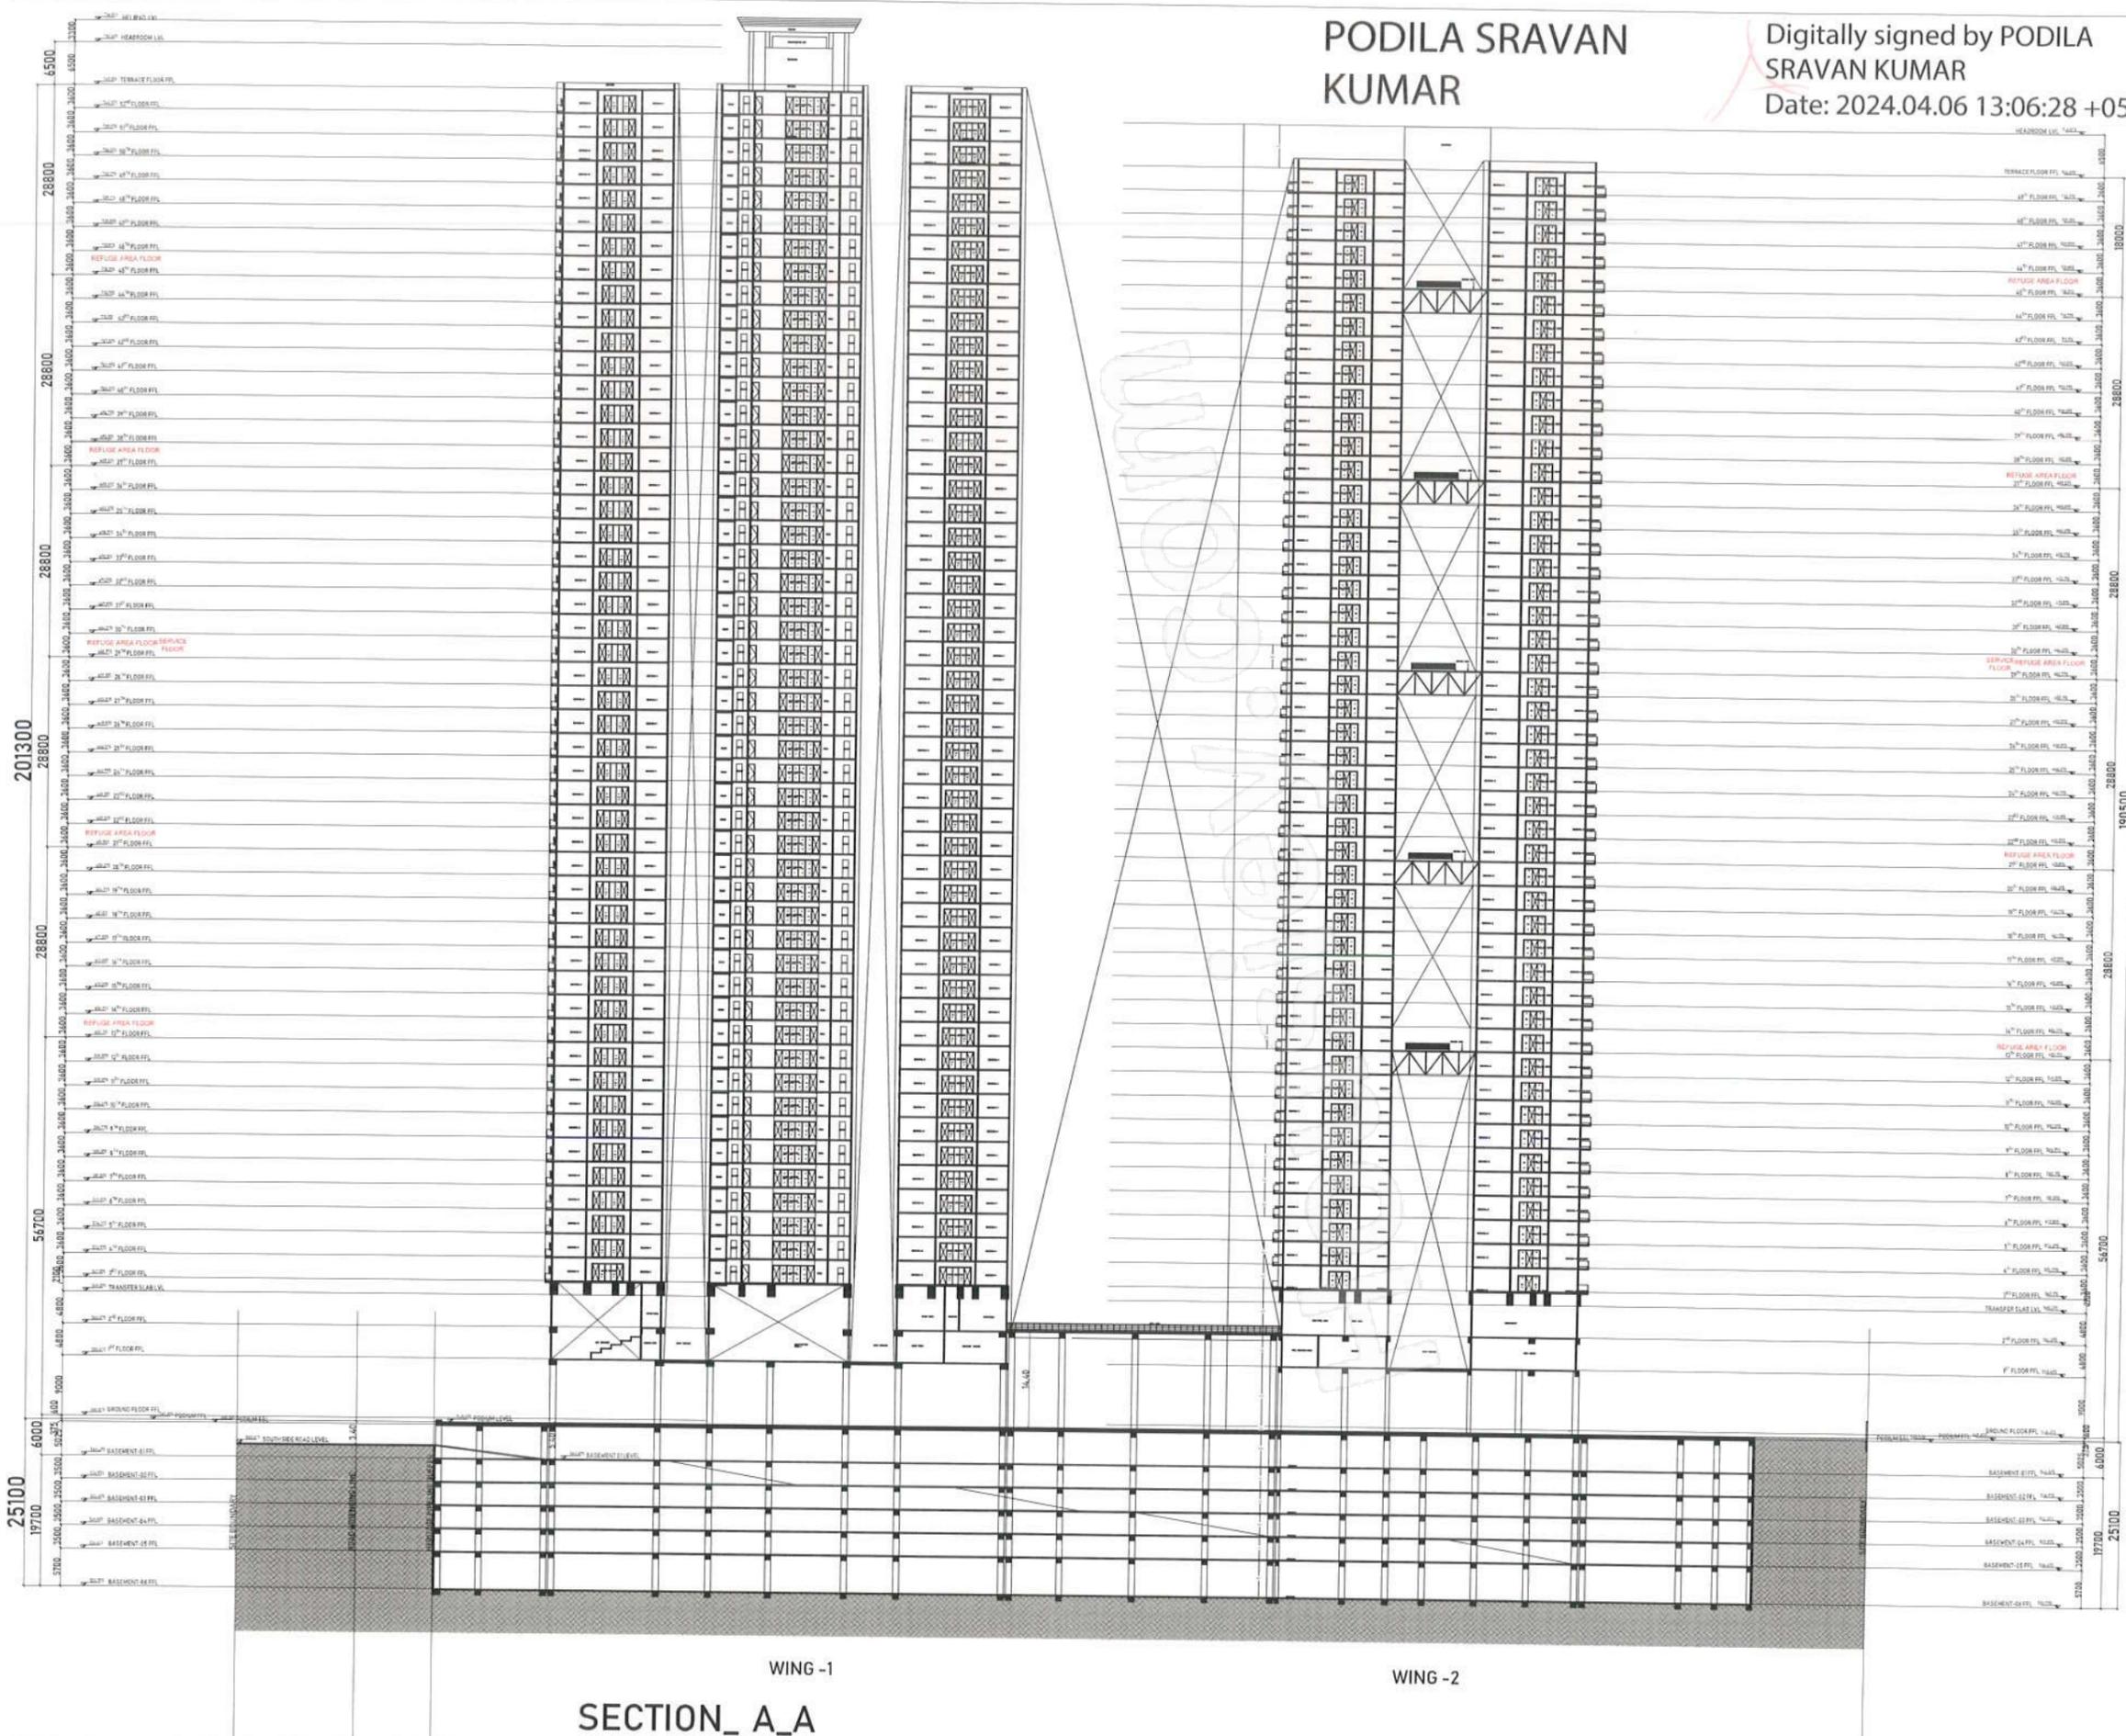

SECTION_A_A

SECTION_B-B

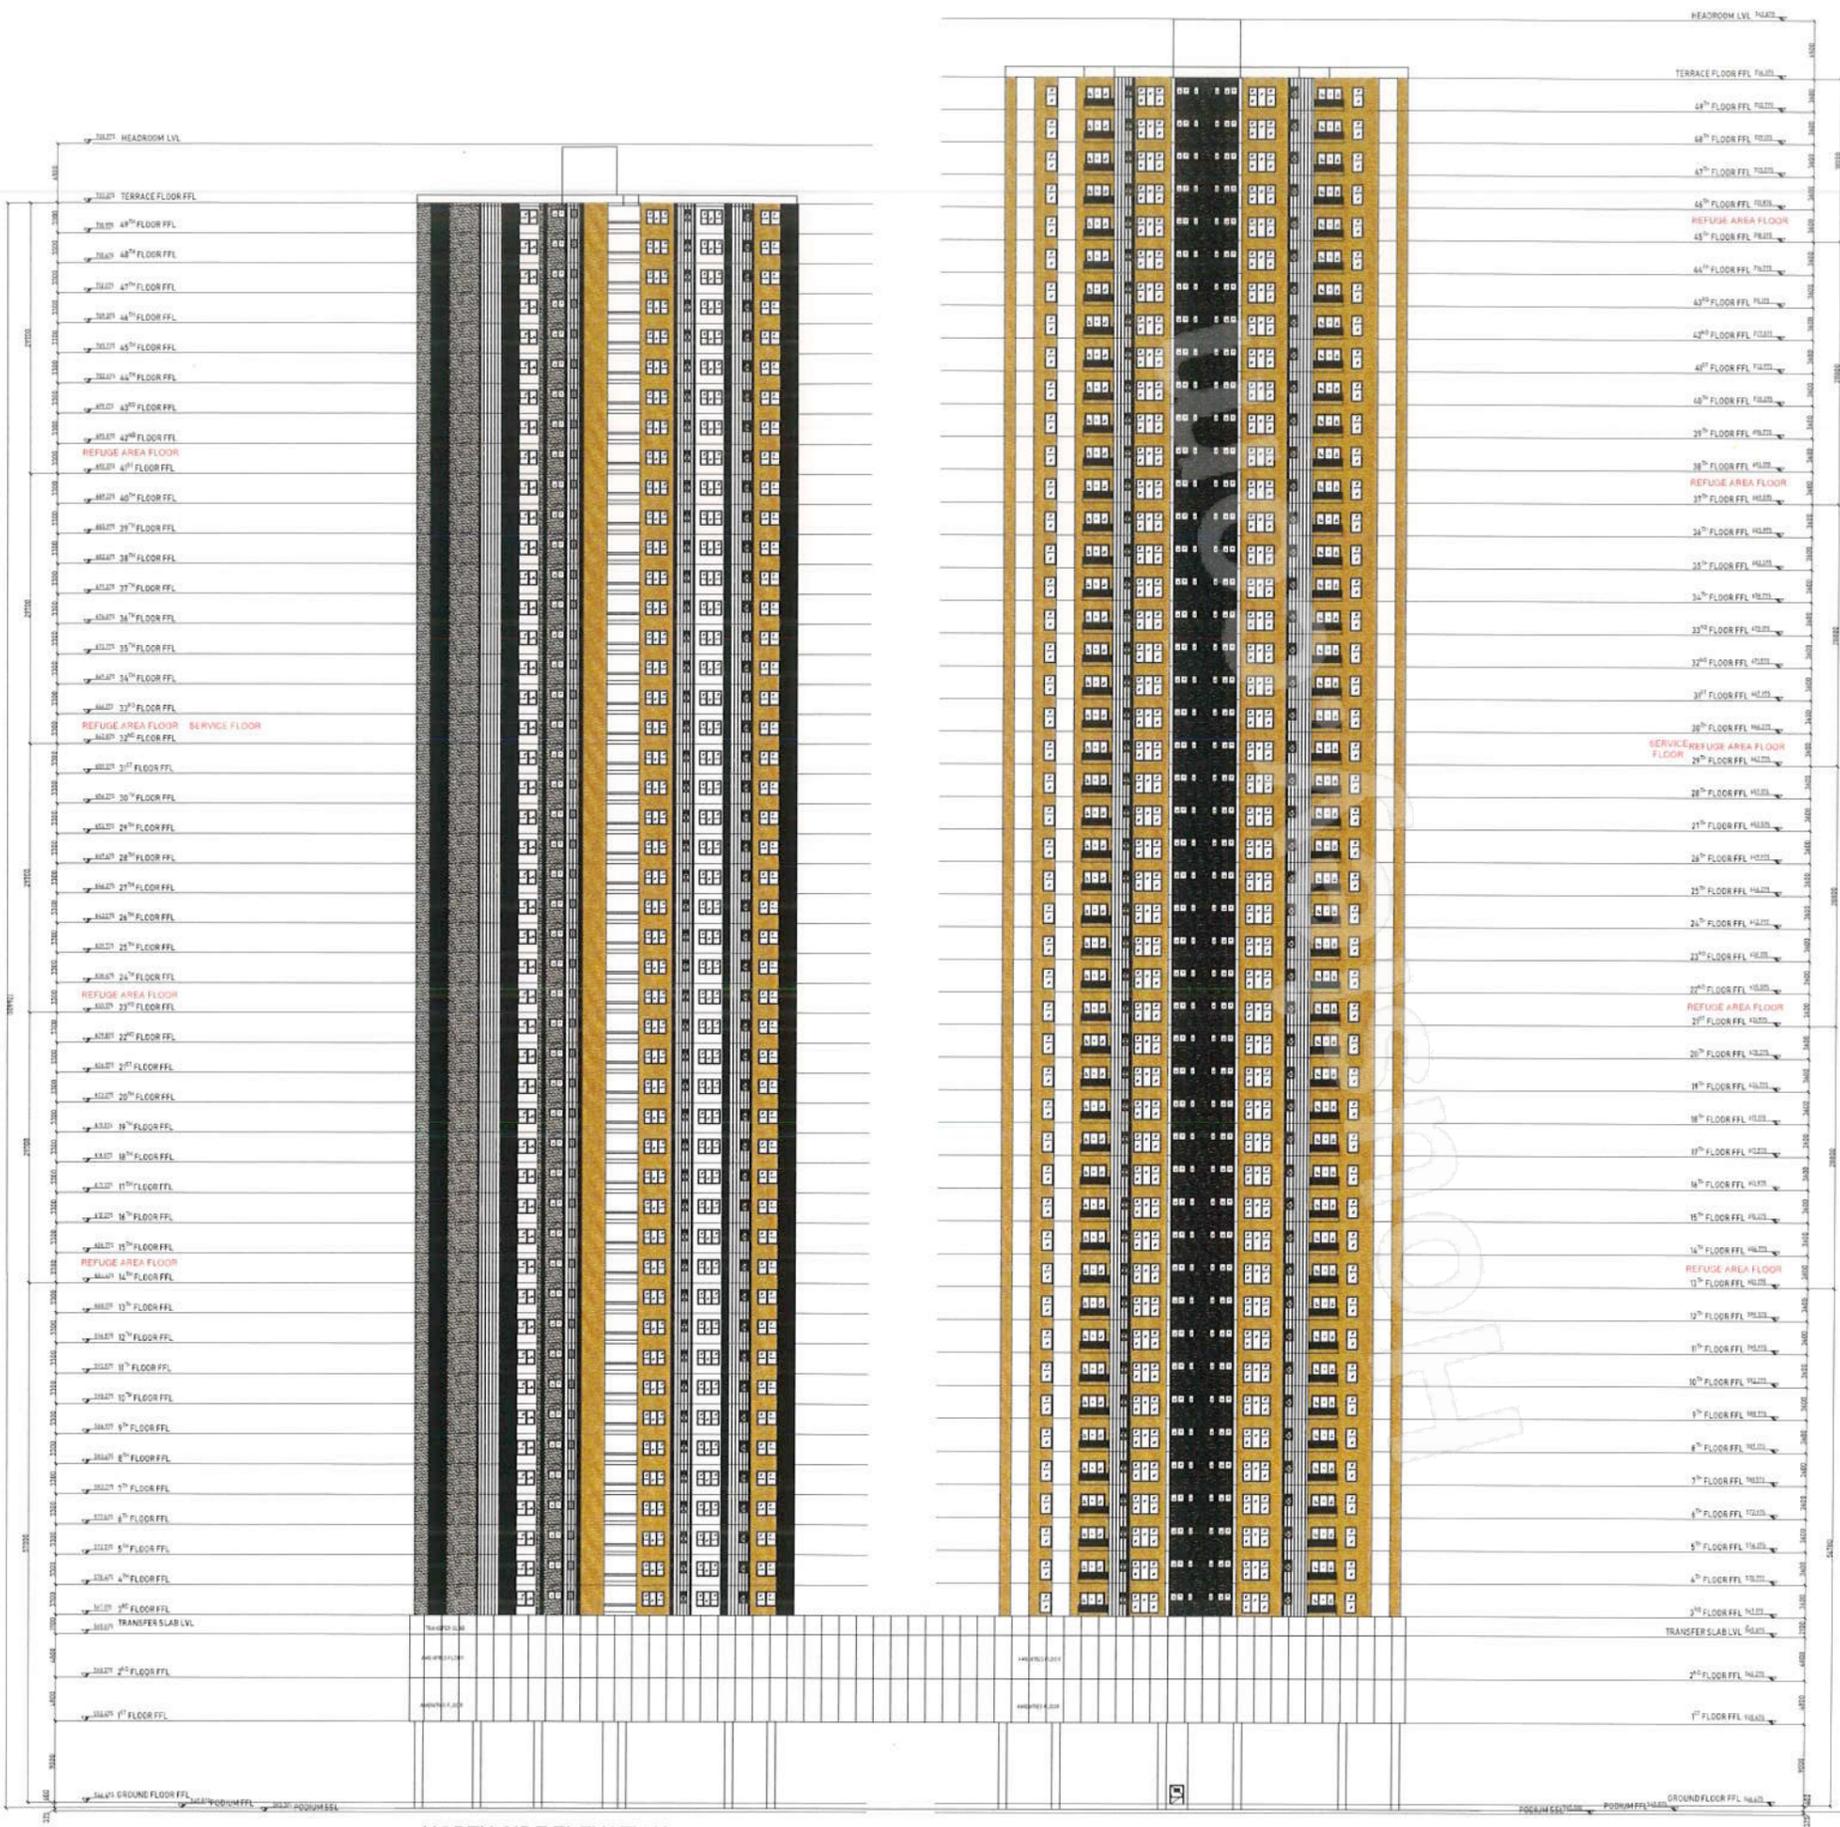

NORTH SIDE ELEVATION

PROJECT TITLE - PLAN SHOWING THE PROPOSED RESIDENTIAL APARTMENTS CONSISTING OF 1 RESIDENTIAL TOWER WITH 3 WINGS EACH CONSISTING OF 6 COMMON BASEMENT + GROUND FLOOR + AMENITIES (1st & 2nd FLOOR) + 52/49/48 UPPER FLOORS (IN WING 1 / 2 / 3) AND ITITES BUILDING IN SY NO 272P & 273P, PUPPALGUDA VILLAGE, GANDIPET MANDAL, RANGAREDDY DISTRICT TELANGANA, REG.

BELONG TO -
MS PHOENIX GLOBAL SPACES PVT LTD

- GENERAL NOTES
- 1 ALL DIMENSIONS IN THIS DRAWING ARE IN MILLIMETERS.
 - 2 ONLY WRITTEN DIMENSIONS ARE TO BE FOLLOWED. THE DRAWING SHOULDNT BE SCALED UNDER ANY CIRCUMSTANCES.
 - 3 ALL MEASUREMENTS MUST BE CHECKED & VERIFIED BY THE CONTRACTORS PRIOR TO EXECUTION OF WORK AT SITE.
 - 4 THIS DRAWING IS TO BE READ IN CONJUNCTION WITH ALL RELEVANT STRUCTURAL, SERVICES & FACILITY PLANNING DRAWINGS.
 - 5 ANY DISCREPANCIES BETWEEN ARCHITECTURAL, STRUCTURAL & SERVICES DRAWINGS MUST BE BROUGHT INTO NOTICE OF THE ARCHITECTS IMMEDIATELY PRIOR TO EXECUTION AT SITE. CO-ORDINATION BETWEEN THE DRAWINGS WHAT SO-EVER IS THE RESPONSIBILITY OF CONTRACTORS.
 - 6 ALL MASONRY WALLS SHOULD BE ALIGNED WITH THE COLUMNS AS INDICATED IN THE DRAWING IRRESPECTIVE OF THE POSITION AS CALCULATED WITH THE DIMENSIONING.
 - 7 FOR DETAILS PLEASE REFER RELEVANT LARGER SCALE DETAILED DRAWINGS AS WHEN INDICATED.
 - 8 IN CASE OF ALL SPECIALIST WORKS, DETAILS AND ANY DEVIATIONS FROM THIS CONSTRUCTION DRAWING THE CONTRACTOR HAS TO PROVIDE SHOP DRAWINGS FOR ARCHITECTS APPROVAL PRIOR TO CONSTRUCTION.

No.	Description	Date

CLIENT:
Phoenix
M/s. PHOENIX GLOBAL SPACES PVT. LTD
A-91233 Road No-40, Jubilee Hills Hyderabad

LEAD CONSULTANT / ARCHITECTS:
ASURE DESIGN STUDIO
308 Floor, 30th Stage One Tower,
Banjara Madhapur Police Station,
Hecht City Road, Hyderabad, Telangana.

STRUCTURAL CONSULTANT:
STRUDDCOM CONSULTANTS PVT. LTD.
OFFICE NO.261, 2ND FLOOR, EKGANTA, CITE NO. 106, PLOT NO. 6,
ERANDOWANE, PUNE-411004

HVAC, ELECTRICAL PHE & FIRE CONSULTANTS:
QDC
QDC INDIA CONSULTING (P) LTD.,
STRUCTURAL & MEP CONSULTANTS
M-2, 2nd Floor, Madhapur Building,
4th Phase, Madhapur, Hyderabad - 500082
PH: 9848102322, www.qdcindia.com




PROJECT TITLE:
PHOENIX P25- TRITON
SURVEY NO 272P 273P
PUPPALGUDA VILLAGE, GANDIPET MANDAL, RANGAREDDY DISTRICT
TELANGANA, REG.

DWG. STATUS:

DWG. TITLE:
WEST SIDE ELEVATION

DATE	SCALE	ORIENTATION
DRAWN	CHECKED	
DRAWING NO.		REVISION

**PODILA
SRAVAN
KUMAR**
Digitally signed
by **PODILA
SRAVAN KUMAR**
Date: 2024.04.06
13:08:34 +05'30'

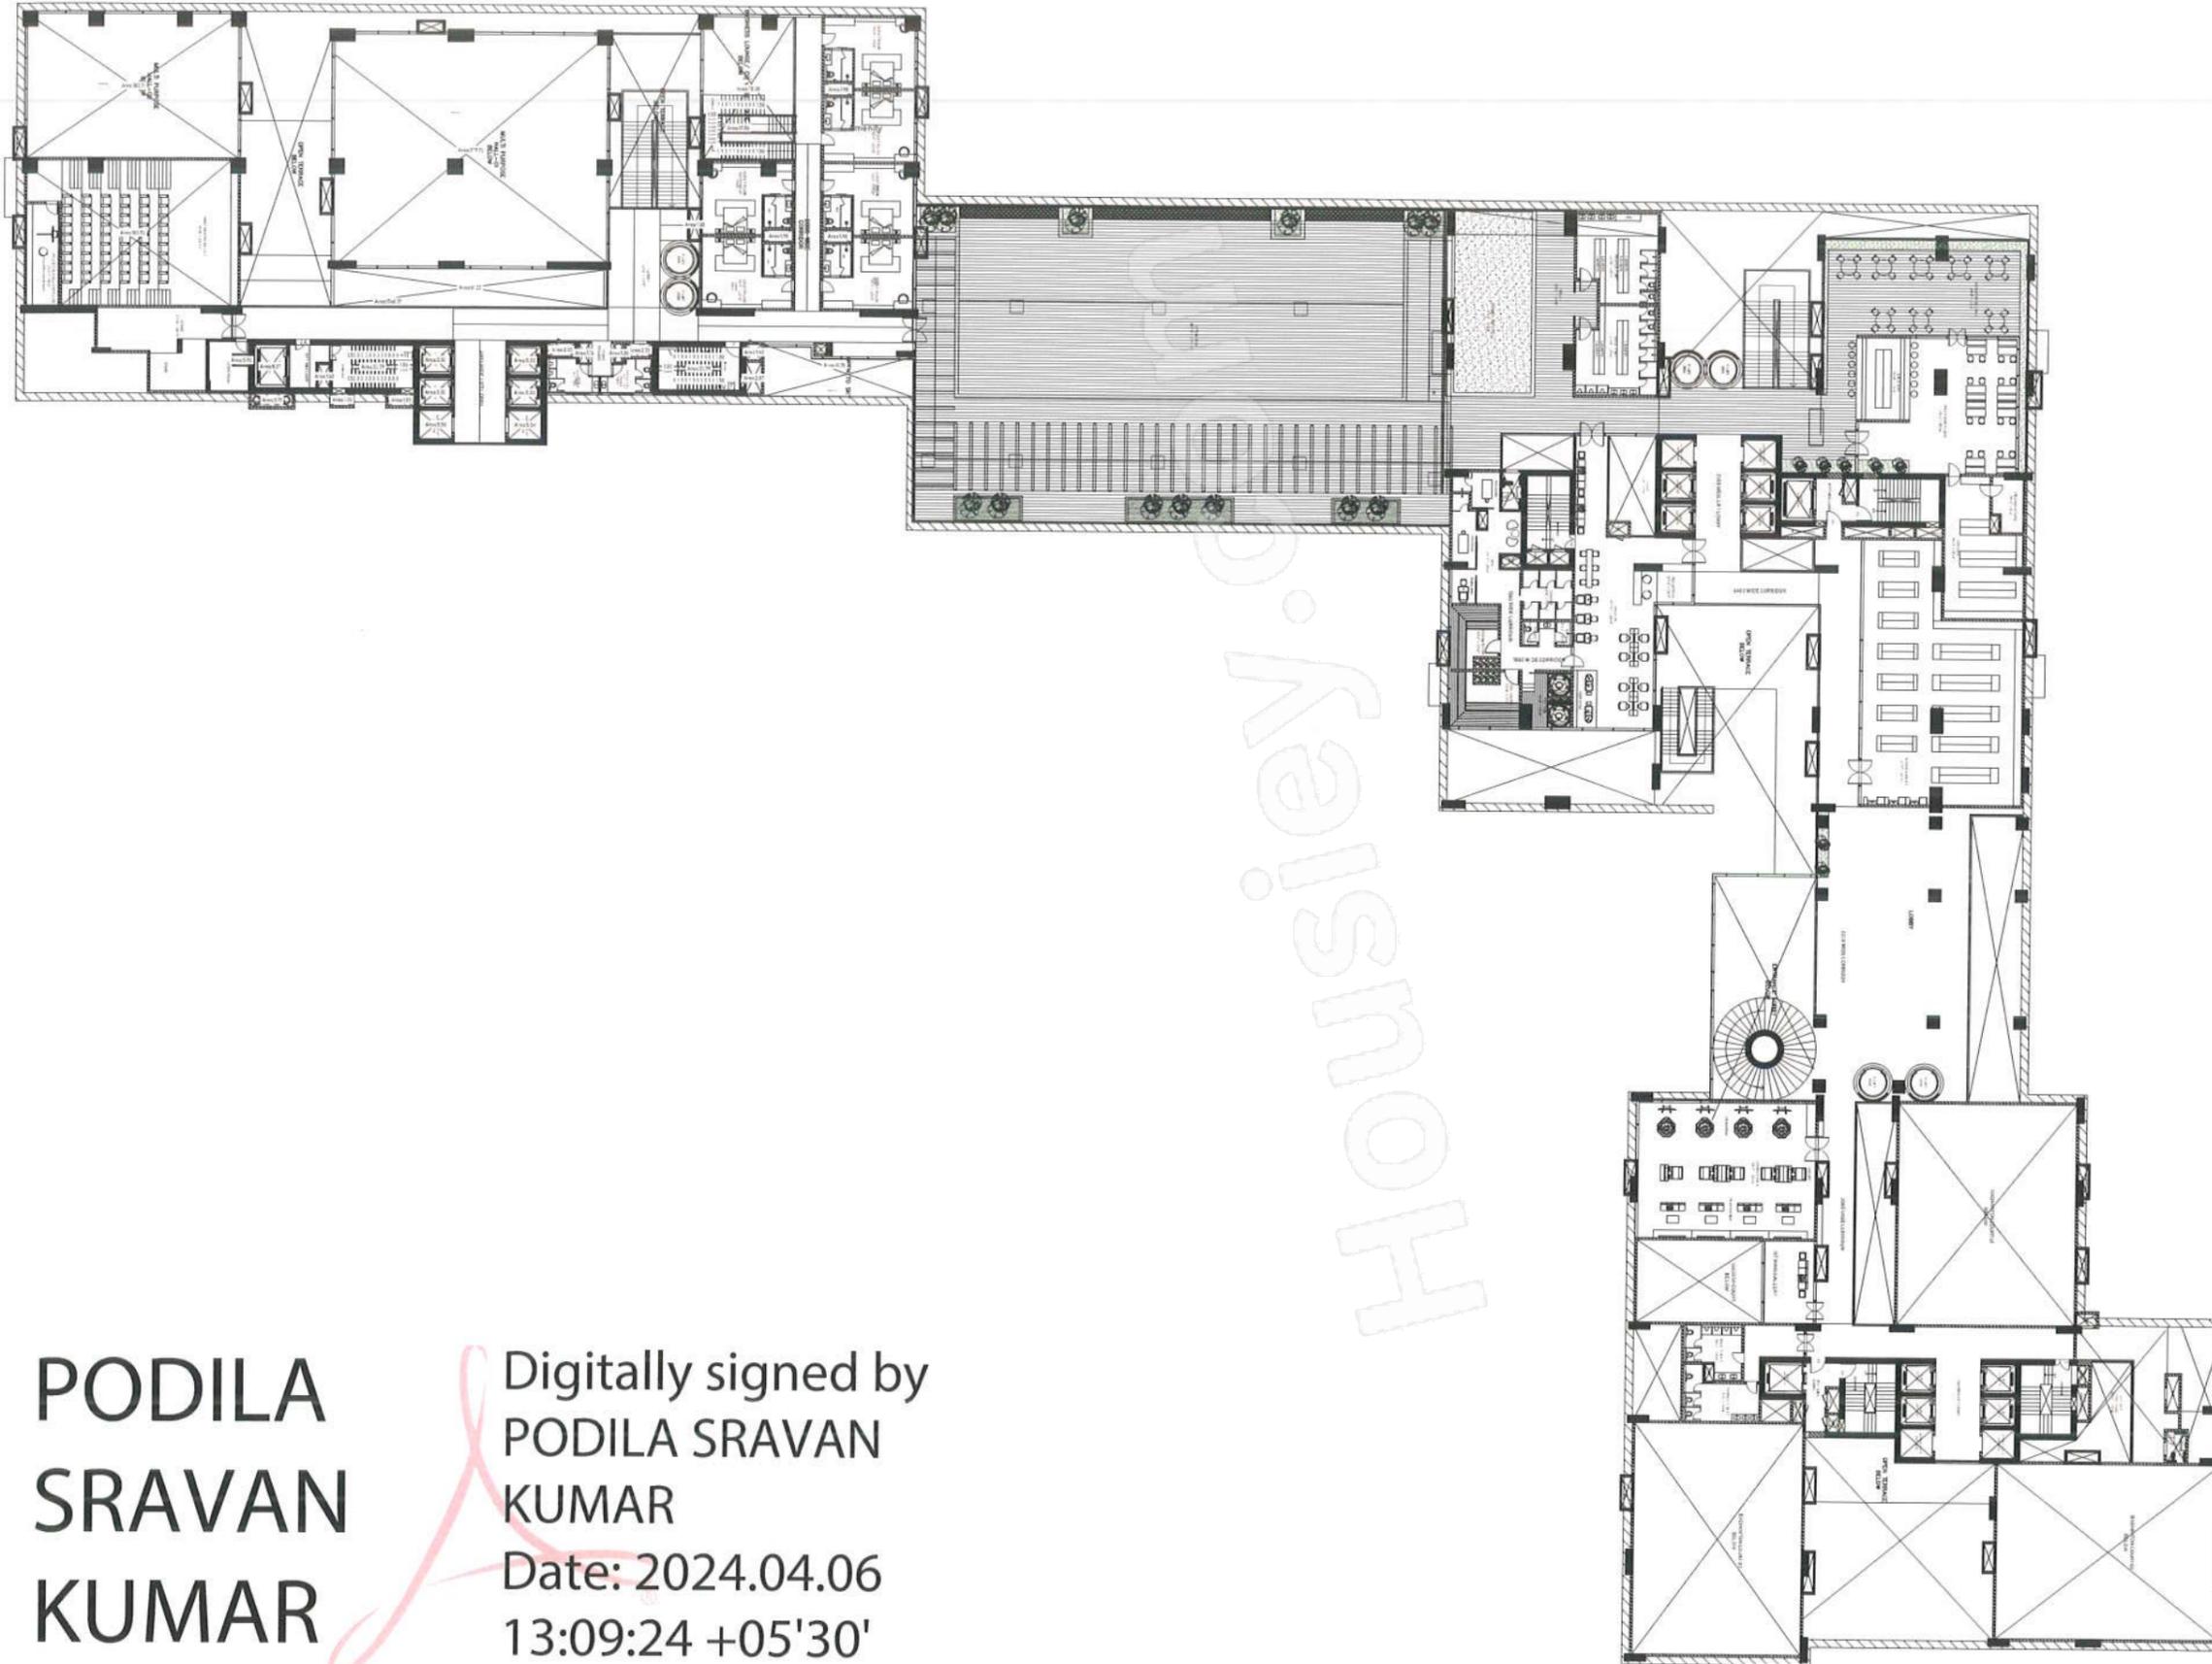

**PODILA
SRAVAN
KUMAR**

Digitally signed by
PODILA SRAVAN
KUMAR
Date: 2024.04.06
13:09:24 +05'30'

PROJECT TITLE - PLAN SHOWING THE PROPOSED RESIDENTIAL APARTMENTS CONSISTING OF 1 RESIDENTIAL TOWER WITH 3 WINGS EACH CONSISTING OF 6 COMMON BASEMENT + GROUND FLOOR + AMENITIES (1st & 2nd FLOOR) + 52/48/48 UPPER FLOORS (IN WING 1, 2, 3) AND FITTED BUILDING IN SY NO 272P & 273P, PUPPALGUDA VILLAGE, GANDIPET MANDAL, RANGAREDDY DISTRICT, TELANGANA-REG.

BELONGS TO -
M/S PHOENIX GLOBAL SPACES PVT LTD

- GENERAL NOTES
1. ALL DIMENSIONS IN THIS DRAWING ARE IN MILLIMETERS.
 2. ONLY WRITTEN DIMENSIONS ARE TO BE FOLLOWED. THE DRAWING SHOULD NOT BE SCALED UNDER ANY CIRCUMSTANCES.
 3. ALL MEASUREMENTS MUST BE CHECKED & VERIFIED BY THE CONTRACTORS PRIOR TO EXECUTION OF WORK AT SITE.
 4. THIS DRAWING IS TO BE READ IN CONJUNCTION WITH ALL RELEVANT STRUCTURAL SERVICES & FACILITY PLANNING DRAWINGS.
 5. ANY DISCREPANCIES BETWEEN ARCHITECTURAL, STRUCTURAL & SERVICES DRAWINGS MUST BE BROUGHT INTO NOTICE OF THE ARCHITECTS IMMEDIATELY PRIOR TO EXECUTION AT SITE. CO-ORDINATION BETWEEN THE DRAWINGS WHAT SO-EVER IS THE RESPONSIBILITY OF CONTRACTORS.
 6. ALL MASONRY WALLS SHOULD BE ALIGNED WITH THE COLLARS AS INDICATED IN THE DRAWING IRRESPECTIVE OF THE POSITION AS CALCULATED WITH THE DIMENSIONING.
 7. FOR DETAILS, PLEASE REFER RELEVANT LARGER SCALE DETAILED DRAWINGS AS WHEN INDICATED.
 8. IN CASE OF ALL SPECIALIST WORKS, DETAILS AND ANY DEVIATIONS FROM THIS CONSTRUCTION DRAWING, THE CONTRACTOR HAS TO PROVIDE SHOP DRAWINGS FOR ARCHITECTS APPROVAL PRIOR TO CONSTRUCTION.

No.	Description	Date

CLIENT:
Phoenix
M/s. PHOENIX GLOBAL SPACES PVT.LTD
A #1235, Road No-42, Jubilee Hills Hyderabad

LEAD CONSULTANT / ARCHITECTS:
ASURE DESIGN STUDIO
2nd Floor, Jyoti Nagar One Tower,
Beside Madhapur Police Station,
Madhapur, Hyderabad, Telangana.

STRUCTURAL CONSULTANT:
STRUDCOM CONSULTANTS PVT. LTD.
OFFICE NO: 201, 2ND FLOOR, ECRANTA, CTS NO: 126 PLOT NO: 8
ERANDOLUVA, PUNE-411004

HVAC, ELECTRICAL PHE & FIRE CONSULTANTS:
QDC
QDC INDIA CONSULTING (P) LTD.,
STRUCTURAL & MEP CONSULTANTS
NO. 7, Raju Mahalaxmi Building,
1st Floor, Madhapur, Hyderabad - 500082
PH: 9848123233, www.qdcindia.com




PROJECT TITLE:
PHOENIX P25- TRITON
SURVEY NO: 272P, 273P
PUPPALGUDA VILLAGE, GANDIPET MANDAL, RANGAREDDY DISTRICT
TELANGANA-REG

DWG_STATUS:

DWG_TITLE: **SECOND FLOOR PLAN**

DATE	SCALE	ORIENTATION
DRAWN	CHECKED	
DRAWING NO		REVISION

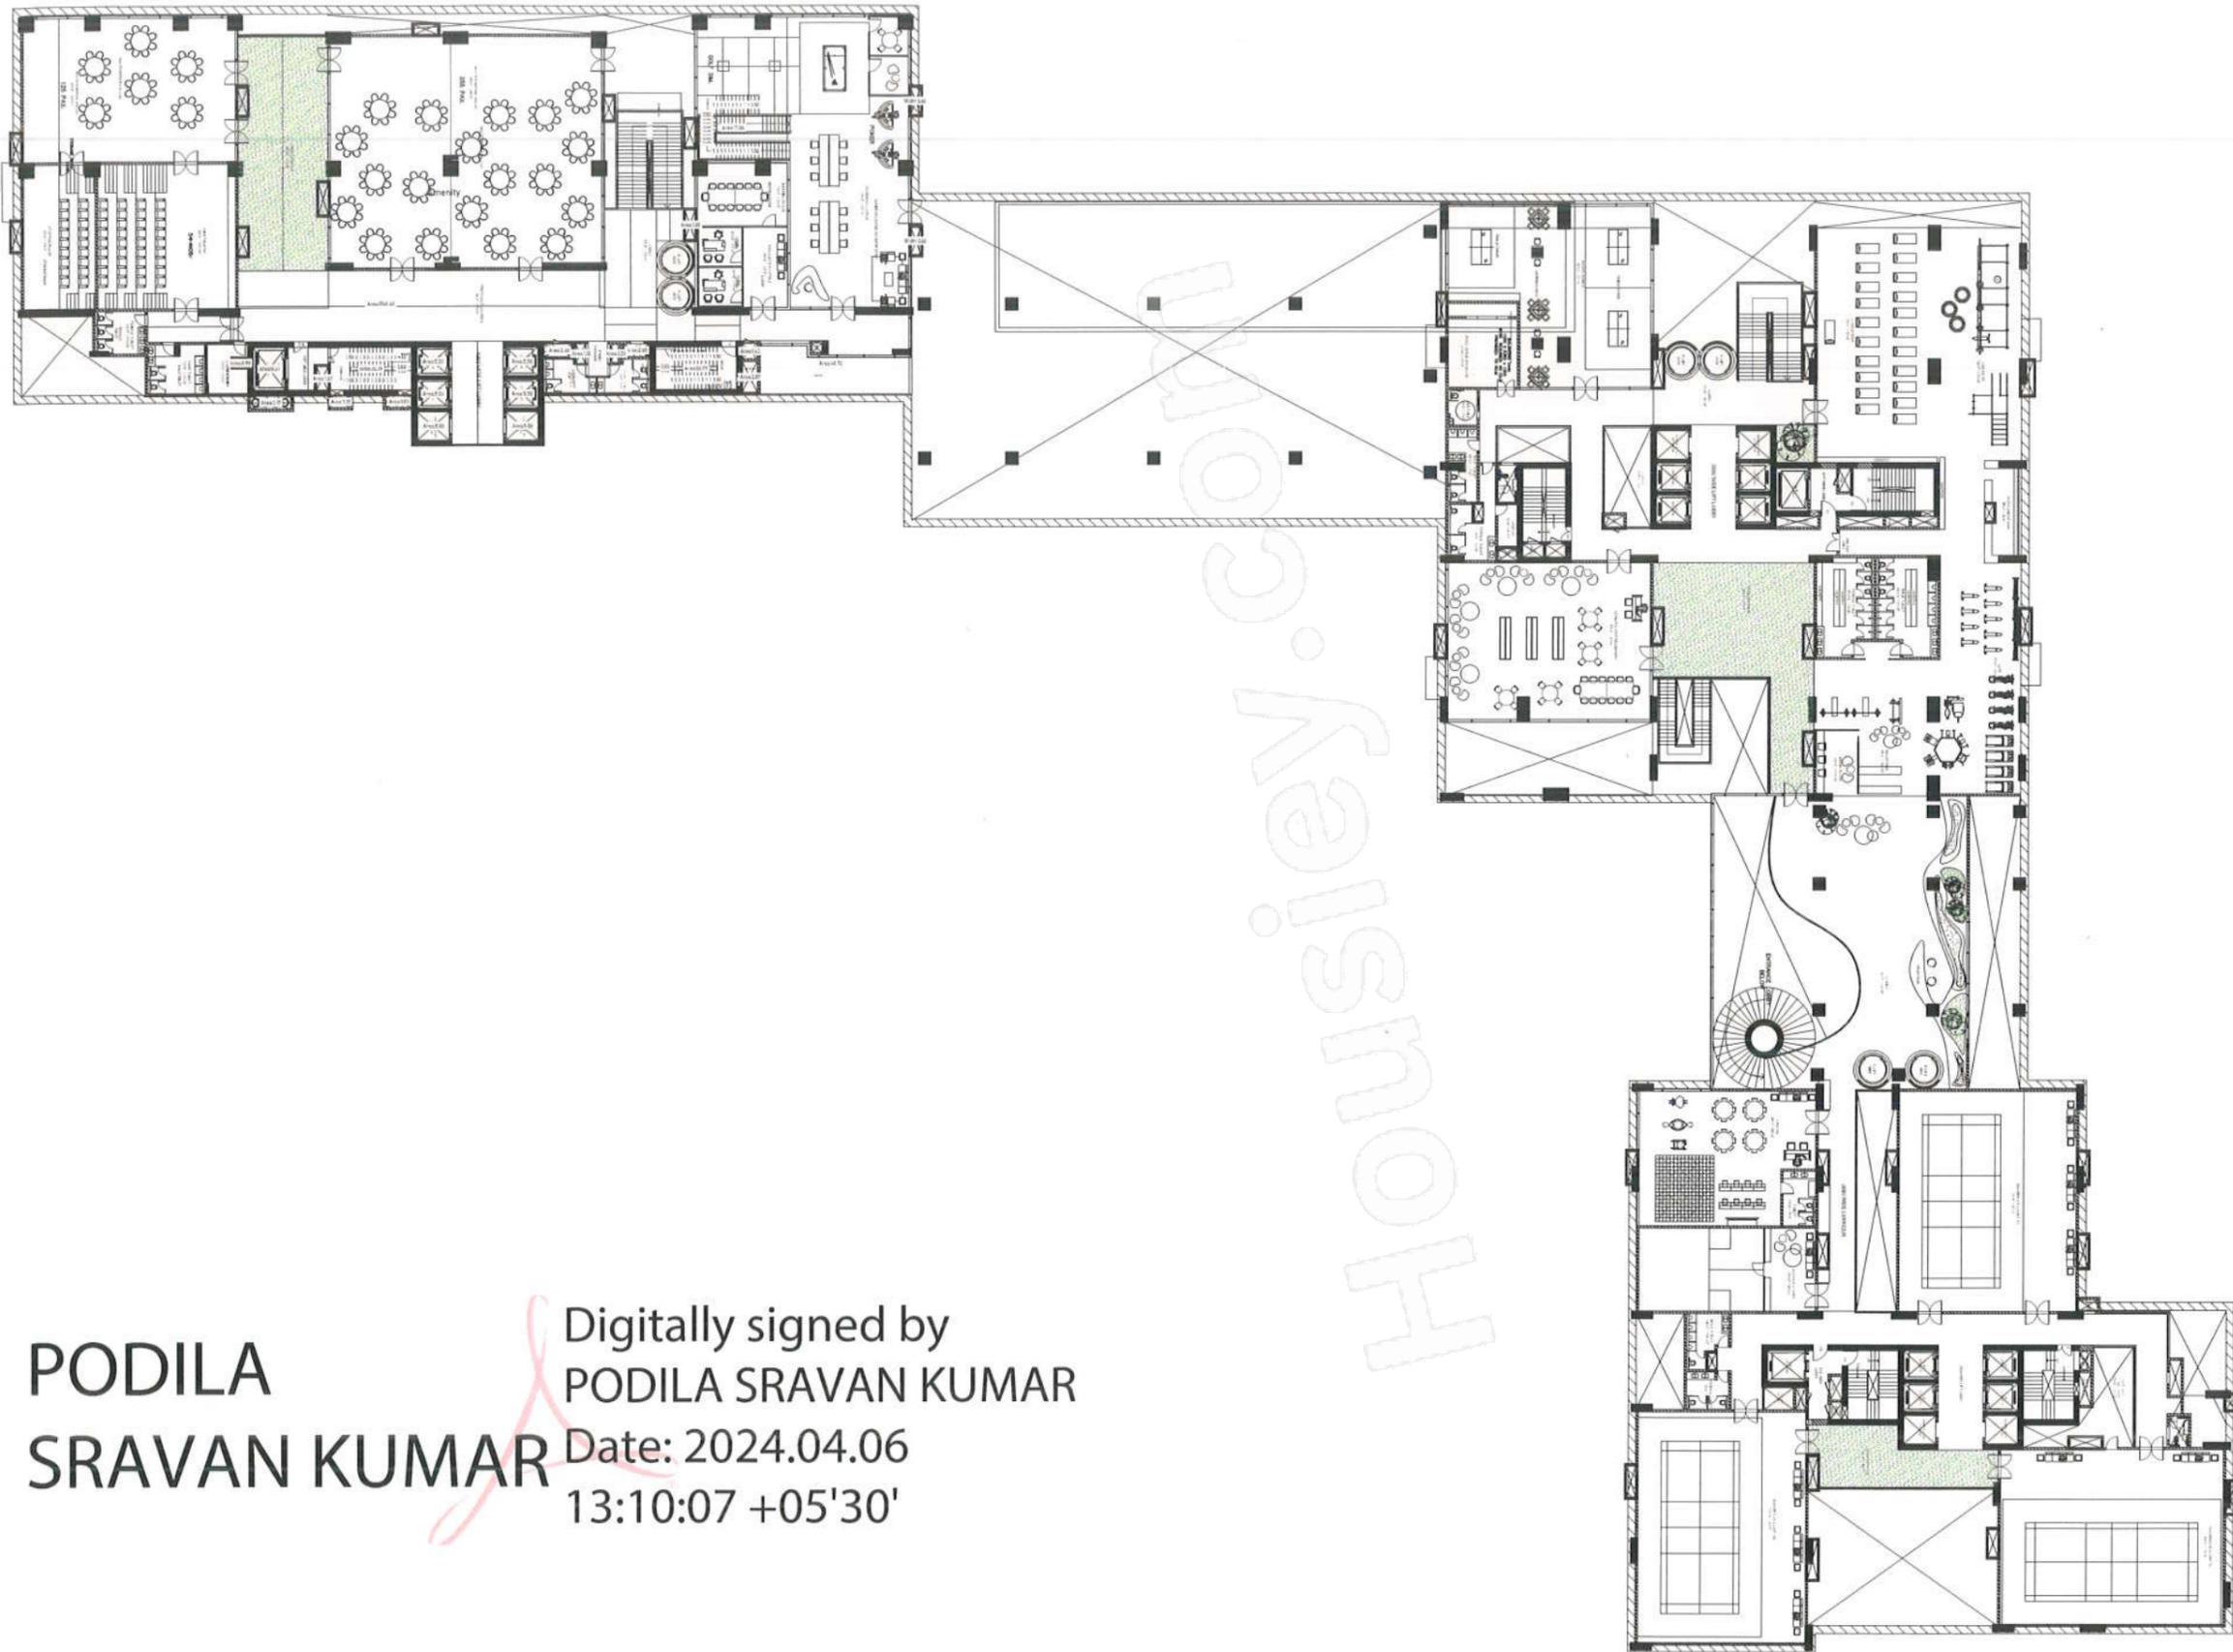

**PODILA
SRAVAN KUMAR**

Digitally signed by
PODILA SRAVAN KUMAR
 Date: 2024.04.06
 13:10:07 +05'30'

PROJECT TITLE - PLAN SHOWING THE PROPOSED RESIDENTIAL APARTMENTS CONSISTING OF 1 RESIDENTIAL TOWER WITH 3 WINGS EACH CONSISTING OF 6 COMMON BASEMENT + GROUND FLOOR + AMENITIES (W/ & 2nd FLOOR) + 2-4/48 UPPER FLOORS (IN WING 1, 2, 3) AND ITITES BUILDING IN SY NO 27P & 27P, PUPPALGUDA VILAGE, GANDUPET MANDAL, RANGAREDDY DISTRICT, TELANGANA, REG.

BELONG TO -
 M/S PHOENIX GLOBAL SPACES PVT LTD

- GENERAL NOTES
1. ALL DIMENSIONS IN THIS DRAWING ARE IN MILLIMETERS.
 2. ONLY WRITTEN DIMENSIONS ARE TO BE FOLLOWED. THE DRAWING SHOULD NOT BE SCALED UNDER ANY CIRCUMSTANCES.
 3. ALL MEASUREMENTS MUST BE CHECKED & VERIFIED BY THE CONTRACTORS PRIOR TO EXECUTION OF WORK AT SITE.
 4. THIS DRAWING IS TO BE READ IN CONJUNCTION WITH ALL RELEVANT STRUCTURAL SERVICES & FACILITY PLANNING DRAWINGS.
 5. ANY DISCREPANCIES BETWEEN ARCHITECTURAL, STRUCTURAL & SERVICES DRAWINGS MUST BE BROUGHT INTO NOTICE OF THE ARCHITECTS IMMEDIATELY PRIOR TO EXECUTION AT SITE CO-ORDINATION BETWEEN THE DRAWINGS WHAT SO-EVER IS THE RESPONSIBILITY OF CONTRACTORS.
 6. ALL MASONRY WALLS SHOULD BE ALIGNED WITH THE COLLUMNS AS INDICATED IN THE DRAWINGS IRRESPECTIVE OF THE POSITION AS CALCULATED WITH THE DIMENSIONING.
 7. FOR DETAILS, PLEASE REFER RELEVANT LARGER SCALE DETAILED DRAWINGS AS WHEN INDICATED.
 8. IN CASE OF ALL SPECIALIST WORKS, DETAILS AND ANY DEVIATIONS FROM THIS CONSTRUCTION DRAWING THE CONTRACTOR HAS TO PROVIDE SHOP DRAWINGS FOR ARCHITECTS APPROVAL PRIOR TO CONSTRUCTION.

No.	Description	Date

CLIENT


M/S. PHOENIX GLOBAL SPACES PVT.LTD
 A # 1225 Road No-49, L.D.Indra Hills Hyderabad

LEAD CONSULTANT / ARCHITECTS
ASURE DESIGN STUDIO
 3rd Floor, Apsara One Tower,
 Hitech Mangalagiri, Pulicat, Chennai,
 Hitech City Road Hyderabad, Telangana.

STRUCTURAL CONSULTANT
STRUDDCOM CONSULTANTS PVT. LTD.
 OFFICE NO.201, 2ND FLOOR, EKAMANTA, CTS NO 136, PLOT NO 8,
 ERANDOWANE, PUNE-411004

HVAC, ELECTRICAL, PHE & FIRE CONSULTANTS

QDC INDIA CONSULTING (P) LTD.,
 STRUCTURAL & MEP CONSULTANTS
 102, P. 2nd Floor, Kalyan Nagar, Bangalore
 102, P. 2nd Floor, Kalyan Nagar, Bangalore
 102, P. 2nd Floor, Kalyan Nagar, Bangalore
 102, P. 2nd Floor, Kalyan Nagar, Bangalore

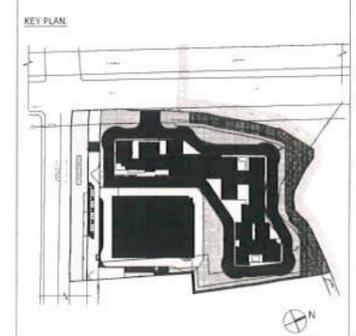

PROJECT TITLE
PHOENIX P25- TRITON
 SURVEY NO 27P, 27P
 PUPPALGUDA VILAGE, GANDUPET MANDAL, RANGAREDDY DISTRICT
 TELANGANA, REG.

DWG. STATUS
FIRST FLOOR PLAN

DATE	SCALE	ORIENTATION
DRAWN	CHECKED	
DRAWING NO.		REVISION

PROJECT TITLE - PLAN SHOWING THE PROPOSED RESIDENTIAL APARTMENTS CONSISTING OF 1 RESIDENTIAL TOWER WITH 3 WINGS EACH CONSISTING OF 6 COMMON BASEMENT + GROUND FLOOR + AMENITIES (1st & 2nd FLOOR) + 52/48 UPPER FLOORS IN WING 1 / 2 / 3) AND ITITES BUILDING IN SY NO 272P & 273P PUPPALGUDA VILLAGE, GANDIPET MANDAL, RANGAREDDY DISTRICT, TELANGANA-REG.

BELONGS TO-

M/S PHOENIX GLOBAL SPACES PVT LTD

GENERAL NOTES

1. ALL DIMENSIONS IN THIS DRAWING ARE IN MILLIMETERS.
2. ONLY WRITTEN DIMENSIONS ARE TO BE FOLLOWED. THE DRAWING SHOULDNT BE SCALED UNDER ANY CIRCUMSTANCES.
3. ALL MEASUREMENTS MUST BE CHECKED & VERIFIED BY THE CONTRACTORS PRIOR TO EXECUTION OF WORK AT SITE.
4. THIS DRAWING IS TO BE READ IN CONJUNCTION WITH ALL RELEVANT STRUCTURAL SERVICES & FACILITY PLANNING DRAWINGS.
5. ANY DISCREPANCIES BETWEEN ARCHITECTURAL, STRUCTURAL & SERVICES DRAWINGS MUST BE BROUGHT INTO NOTICE OF THE ARCHITECTS IMMEDIATELY PRIOR TO EXECUTION AT SITE. CO-ORDINATION BETWEEN THE DRAWINGS WHAT SO-EVER IS THE RESPONSIBILITY OF CONTRACTORS.
6. ALL MASONRY WALLS SHOULD BE ALIGNED WITH THE COLLARS AS INDICATED IN THE DRAWING IRRESPECTIVE OF THE POSITION AS CALCULATED WITH THE DIMENSIONING.
7. FOR DETAILS, PLEASE REFER LARGER SCALE DETAILED DRAWINGS AS WHEN INDICATED.
8. IN CASE OF ALL SPECIALIST WORKS, DETAILS AND ANY DEVIATIONS FROM THIS CONSTRUCTION DRAWING, THE CONTRACTOR HAS TO PROVIDE SHOP DRAWINGS FOR ARCHITECTS APPROVAL PRIOR TO CONSTRUCTION.

No.	Description	Date

CLIENT:



M/s. PHOENIX GLOBAL SPACES PVT. LTD
A #1535 Road No-48, Jubilee Hills, Hyderabad

LEAD CONSULTANT / ARCHITECTS:

ASURE DESIGN STUDIO
3rd Floor, Asuram One Tower,
Beside Madhapur Police Station,
Hitech City Road, Hyderabad, Telangana.

STRUCTURAL CONSULTANT:


STRUDCOM CONSULTANTS PVT. LTD.
OFFICE NO 201, 2ND FLOOR, EKANTARA, CTS NO 136, PLOT NO 8,
ERANDURANE, PUNE-411004

HVAC, ELECTRICAL PHE & FIRE CONSULTANTS:



QDC INDIA CONSULTING (P) LTD.,
STRUCTURAL & MEP CONSULTANTS
M2, F, North Mahabubnagar Building,
3rd Floor, Hyderabad, Telangana-500011
91-80-99151143, www.qdc-india.com

KEY PLAN:

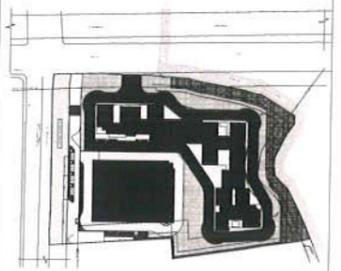

PROJECT TITLE:

PHOENIX P25- TRITON

SURVEY NO 272P, 273P
PUPPALGUDA VILLAGE, GANDIPET MANDAL, RANGAREDDY DISTRICT,
TELANGANA-REG.

DWG STATUS:


DWG TITLE:


BASEMENT 6

DATE	SCALE	ORIENTATION
DRAWN	CHECKED	
DRAWING NO.		REVISION

PODILA
SRAVAN KUMAR

Digitally signed by
PODILA SRAVAN KUMAR
Date: 2024.04.06 13:11:04
+05'30'

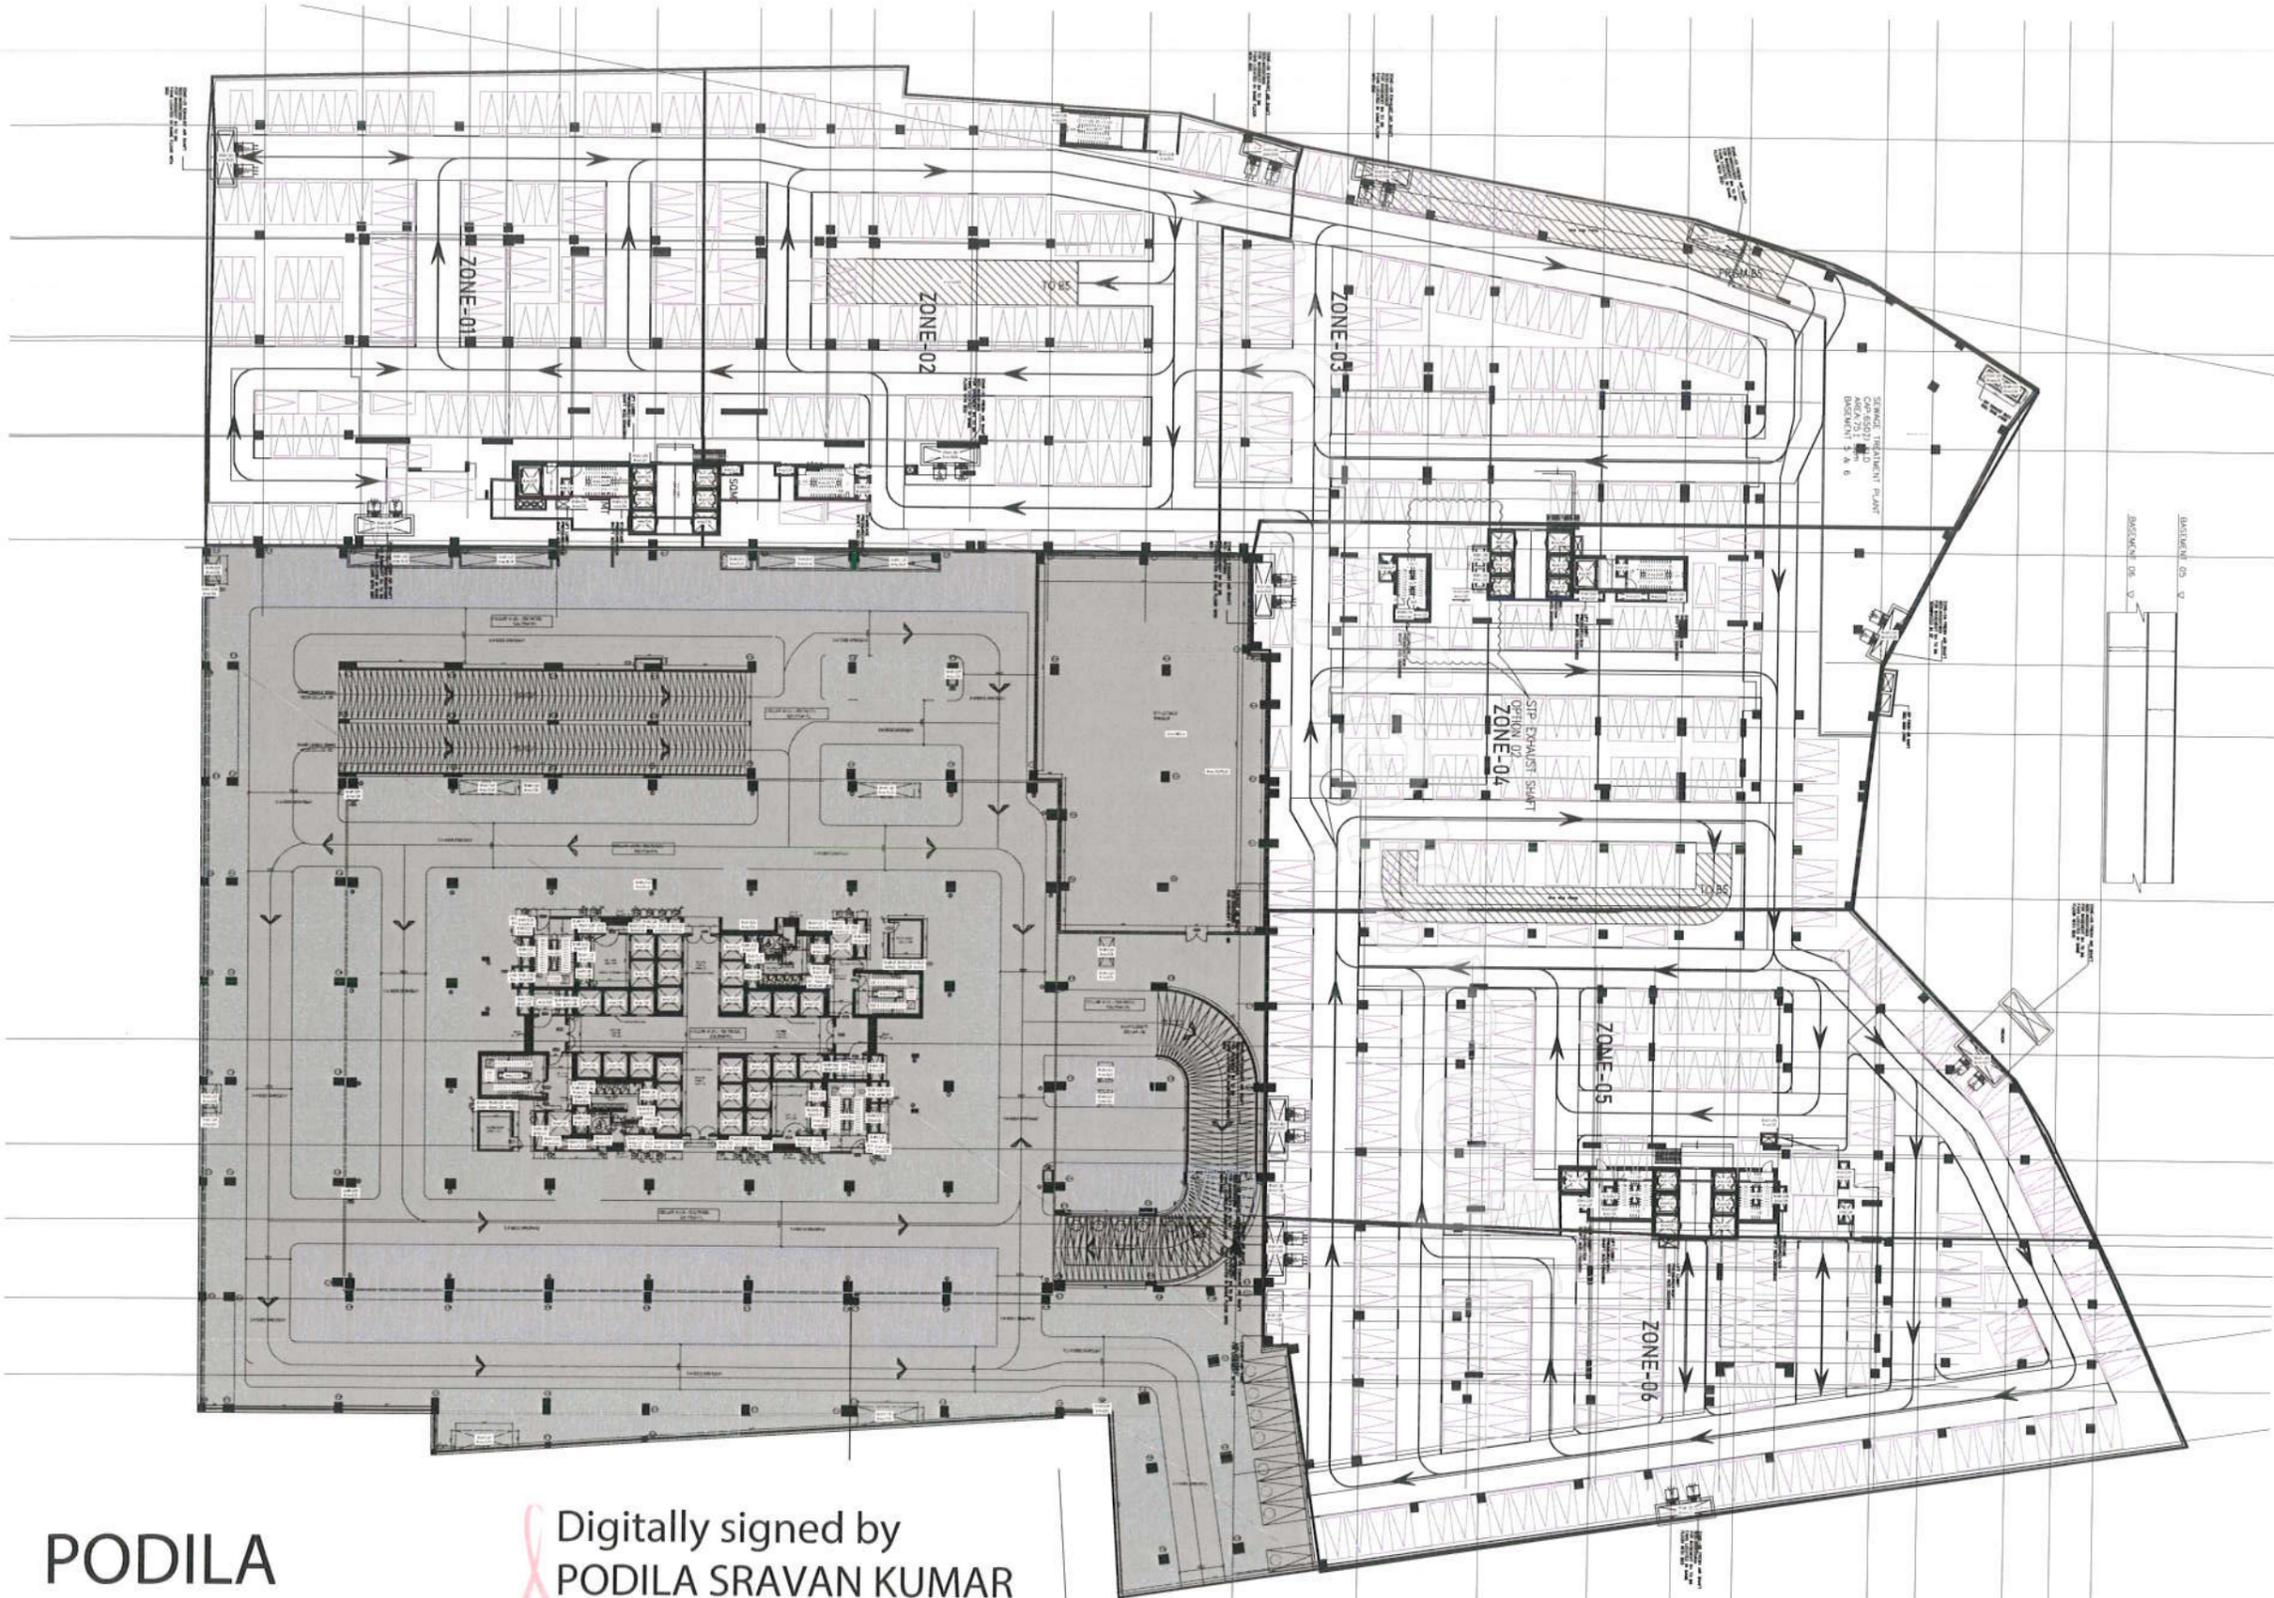

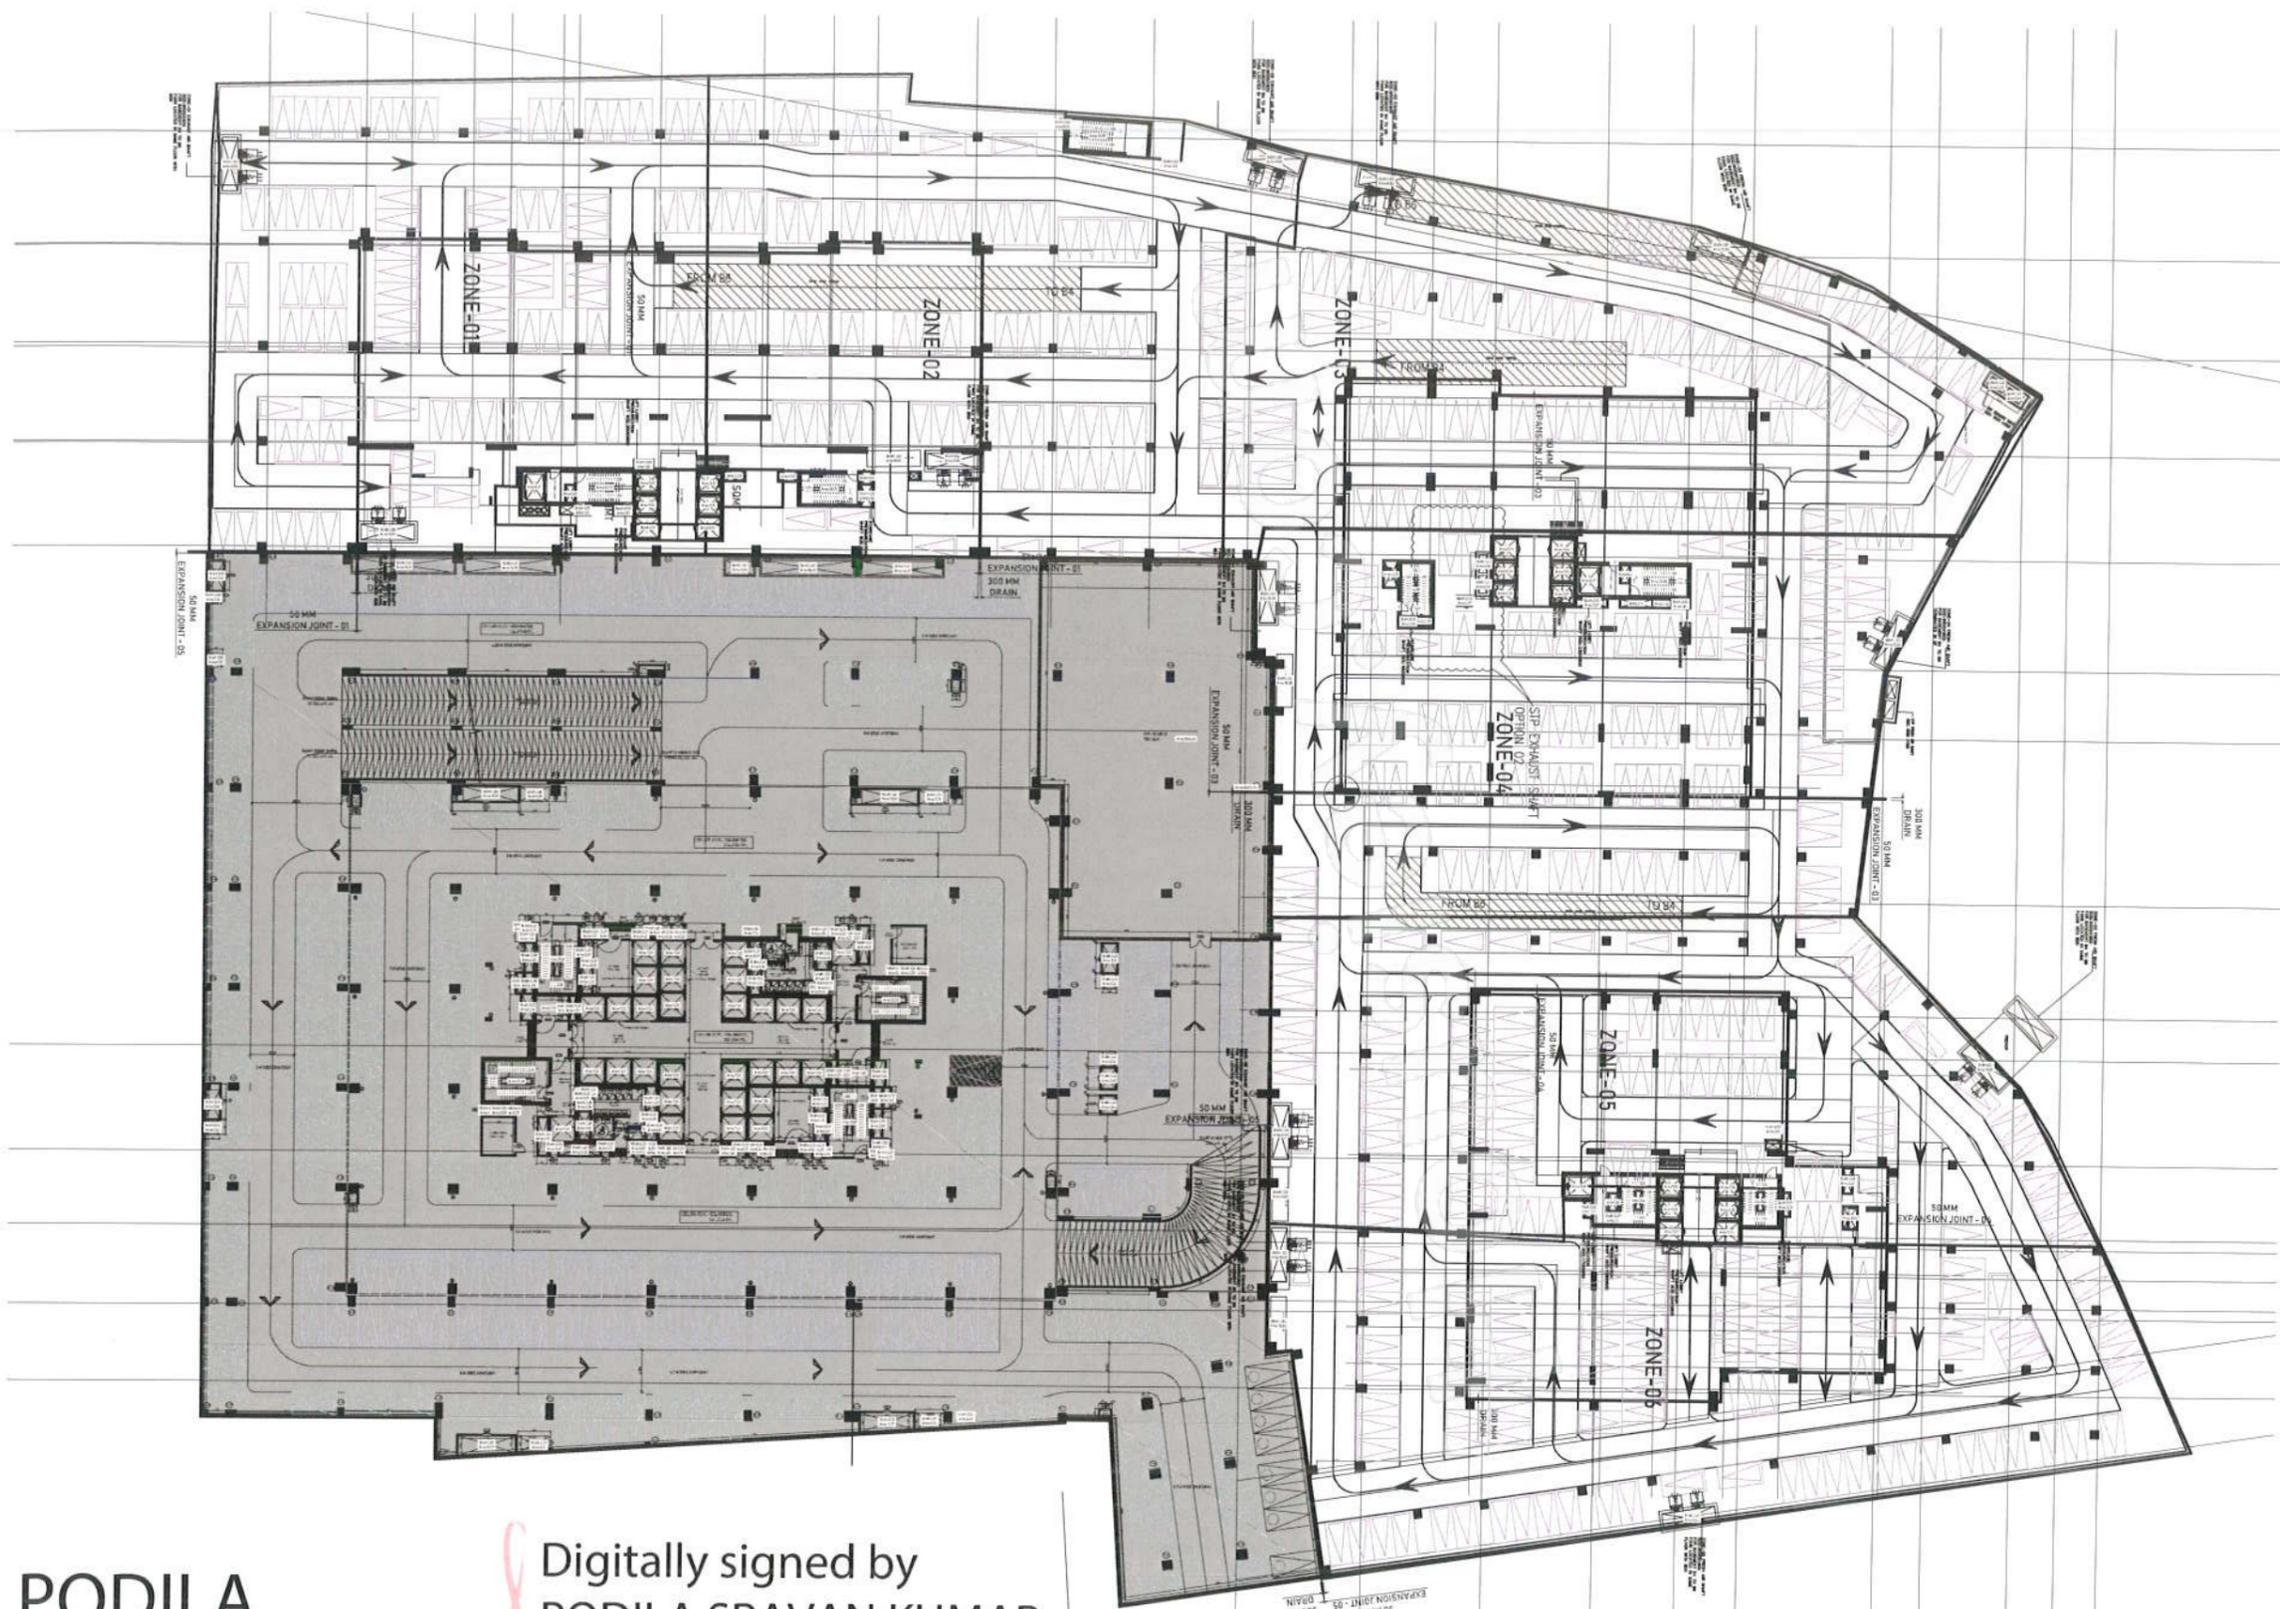

**PODILA
SRAVAN KUMAR**

Digitally signed by
PODILA SRAVAN KUMAR
 Date: 2024.04.06
 13:11:55 +05'30'

PROJECT TITLE - PLAN SHOWING THE PROPOSED RESIDENTIAL APARTMENTS CONSISTING OF 1 RESIDENTIAL TOWER WITH 3 WINGS EACH CONSISTING OF 4 COMMON BASEMENT + GROUND FLOOR + AMENITIES (1st & 2nd FLOOR) + 52/49/48 UPPER FLOORS (IN WING 1, 2, 3) AND FITTES BUILDING IN SY NO 272P & 273P, PUPPALGUDA VILLAGE, GANDIPET MANDAL, RANGAREDDY DISTRICT, TELANGANA-REG.

BELONG TO:-

M/S PHOENIX GLOBAL SPACES PVT LTD

GENERAL NOTES

1. ALL DIMENSIONS IN THIS DRAWING ARE IN MILLIMETERS.
2. ONLY WRITTEN DIMENSIONS ARE TO BE FOLLOWED. THE DRAWING SHOULD NOT BE SCALED UNDER ANY CIRCUMSTANCES.
3. ALL MEASUREMENTS MUST BE CHECKED & VERIFIED BY THE CONTRACTORS PRIOR TO EXECUTION OF WORK AT SITE.
4. THIS DRAWING IS TO BE READ IN CONJUNCTION WITH ALL RELEVANT STRUCTURAL SERVICES & FACILITY PLANNING DRAWINGS.
5. ANY DISCREPANCIES BETWEEN ARCHITECTURAL, STRUCTURAL & SERVICES DRAWINGS MUST BE BROUGHT INTO NOTICE OF THE ARCHITECTS IMMEDIATELY PRIOR TO EXECUTION AT SITE. CO-ORDINATION BETWEEN THE DRAWINGS WHAT SO-EVER IS THE RESPONSIBILITY OF CONTRACTORS.
6. ALL MASONRY WALLS SHOULD BE ALIGNED WITH THE COLUMNS AS INDICATED IN THE DRAWING IRRESPECTIVE OF THE POSITION AS CALCULATED WITH THE DIMENSIONING.
7. FOR DETAILS, PLEASE REFER RELEVANT LARGER SCALE DETAILED DRAWINGS AS WHEN INDICATED.
8. IN CASE OF ALL SPECIALIST WORKS, DETAILS AND ANY DEVIATIONS FROM THIS CONSTRUCTION DRAWING, THE CONTRACTOR HAS TO PROVIDE SHOP DRAWINGS FOR ARCHITECTS APPROVAL PRIOR TO CONSTRUCTION.

No.	Description	Date

CLIENT:



M/s. PHOENIX GLOBAL SPACES PVT. LTD
 A#1333 Road No-45, Jubilee Hills Hyderabad

LEAD CONSULTANT (ARCHITECTS):

ASURE DESIGN STUDIO
 3rd Floor, Prongga Cine Tower,
 Beside Madhapur Police Station,
 Hitech City Road Hyderabad Telangana.

STRUCTURAL CONSULTANT:


STRUDDCOM CONSULTANTS PVT. LTD.
 OFFICE NO. 201, 2ND FLOOR, ERDANTA, CTS NO. 138, PLOT NO. 8,
 ERANDOLLA, PUNE-411004

HVAC, ELECTRICAL, PHE & FIRE CONSULTANTS:



QDC INDIA CONSULTING (P) LTD.,
 STRUCTURAL & MEP CONSULTANTS
 W-2, Tughlakabad-Bypass
 4th Floor, Tughlakabad-Bypass, Sec-12
 DELHI-110021, www.qdcindia.com

KEY PLAN:

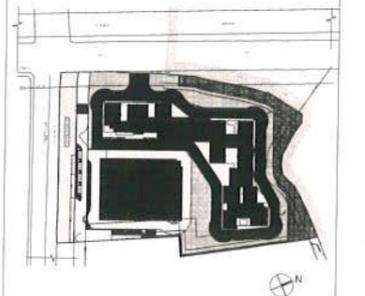

PROJECT TITLE:

PHOENIX P25- TRITON
 SURVEY NO 272P/273P
 PUPPALGUDA VILLAGE, GANDIPET MANDAL, RANGAREDDY DISTRICT,
 TELANGANA-REG.

DWG STATUS:

DWG TITLE:

BASEMENT 5

DATE	SCALE	ORIENTATION
DRAWN	CHECKED	
DRAWNO NO	REVISION	